PROPOSED SITE MODIFICATIONS

Amherst Development Park 6000 - 6040 N.Bailey Ave, Amherst, NY BDC Property # 1723 SITE DEVELOPMENT DRAWINGS

INDEX OF DRAWINGS

DWG.#	DRAWING NAME	REVISION	DATE
C1.0 C2.0	COVER SHEET EXISTING SURVEY	16	11.06.2025
C3.00	DEMOLITION & EROSION CONTROL PLAN WEST	16	11.06.2025
C3.01	DEMOLITION & EROSION CONTROL PLAN EAST	14	08.01.2025
C3.10	DEMOLITION & EROSION CONTROL PLAN DETAILS	6	08.30.2024
C4.0	OVERALL SITE PLAN	16	11.06.2025
C4.01	OVERALL SITE EASEMENT PLAN		11.06.2025
C4.10	DETAILED SITE PLAN WEST	16	11.06.2025
C4.11	DETAILED SITE PLAN EAST	16	11.06.2025
C4.20	CONSTRUCTION DETAILS	13	06.23.2025
C4.21	CONSTRUCTION DETAILS		11.06.2025
C5.00	GRADING PLAN WEST	16	11.06.2025
C5.01	GRADING PLAN EAST	16	11.06.2025
C5.10	DRAINAGE PLAN WEST	16	11.06.2025
C5.11	DRAINAGE PLAN EAST	16	11.06.2025
C5.20	DRAINAGE DETAILS	12	05.16.2025
C5.21	DRAINAGE DETAILS	14	08.01.2025
C6.00	UTILITY PLAN WEST	16	11.06.2025
C6.01	UTILITY PLAN EAST	16	11.06.2025
C6.10	UTILITY DETAILS	7	12.03.2024
C7.0 - C7.4	LANDSCAPING PLANS	7	08.12.2025
C8.0	SITE LIGHTING PLAN	14	08.01.2025
C8.10	LIGHTING DETAILS	10	02.05.2025

OWNER/DEVELOPER:

NAME: BENDERSON DEVELOPMENT COMPANY, LLC ADDRESS: 570 DELAWARE AVENUE, BUFFALO, NY 14202

CONTACT: DAVID ZUPPELLI PHONE: 716 - 878 - 9683



BENDERSON DEVELOPMENT COMPANY, LLC

570 Delaware Ave. Buffalo, New York 14202

SURVEYOR

NAME: COSTICH ENGINEERING

ADDRESS: 217 LAKE AVE ROCHESTER NY 14608

CONTACT: DAN HICKOK PHONE: 585-485-3020

UTILITIES:

NATURAL GAS

NAME/TITLE: WILLIAM SCHNEIDER

COMPANY/DEPT: NATURAL FUEL GAS

ADDRESS:
PHONE: 716 - 696 - 6460

TELEPHONE COMPANY

NAME/TITLE: JOHN HECKMAN
COMPANY/DEPT: VERIZON
ADDRESS: -

PHONE: 716 - 840 - 8603

ELECTRIC

COMPANY/DEPT: NATIONAL GRID ADDRESS: -

DIC SAEELV NEW VOD

PHONE: 1 - 800 - 962 - 7962 OR (811)

AGENCIES:

ENGINEERING DEPARTMENT

NAME/TITLE: JEFF BURROUGHS

COMPANY/DEPT: TOWN OF AMHERST, NY - ENGINEERING DPT ADDRESS: 1100 NORTH FOREST RD, WILLIAMSVILLE, NY

PHONE: 716 - 631 - 7154 EX 7418

BUILDING & PLUMBING DEPARTMENT

NAME/TITLE: MARK BERKE
COMPANY/DEPT: TOWN OF AMHERST, NY - BUILDING DPT

ADDRESS: 5583 MAIN STREET, WILLIAMSVILLE, NY 14221


PHONE: 716 - 631 - 708


PLANNING DEPARTMENT

NAME/TITLE: DAN HOWARD


COMPANY/DEPT: TOWN OF AMHERST, NY - PLANNING DPT ADDRESS: 5583 MAIN STREET, WILLIAMSVILLE, NY 14221

ADDRESS: 5583 MAIN STRE PHONE: 716 - 631 - 7051

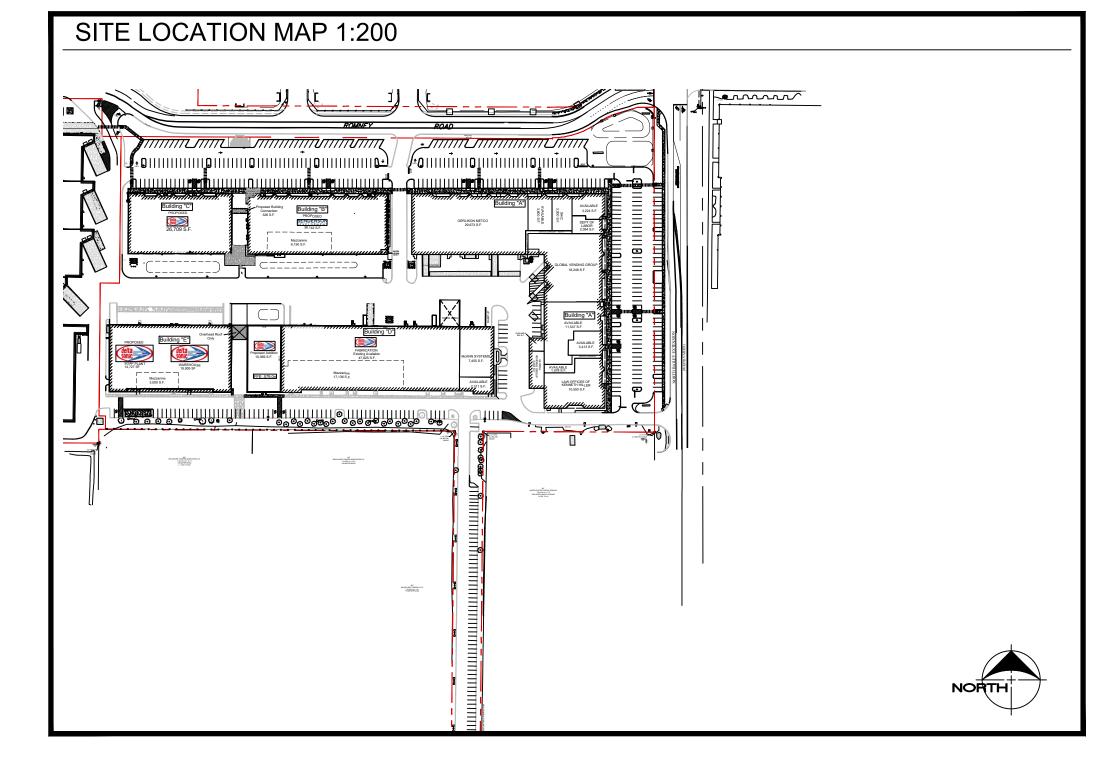

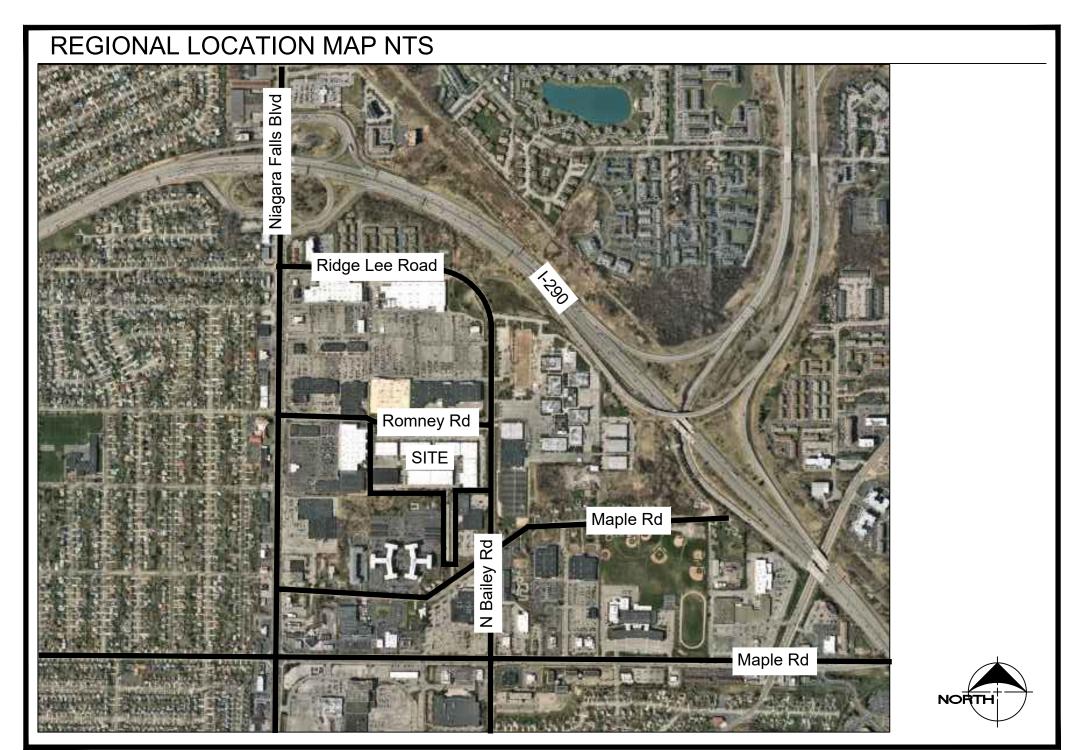

OFFICIAL TOWN USE ONLY

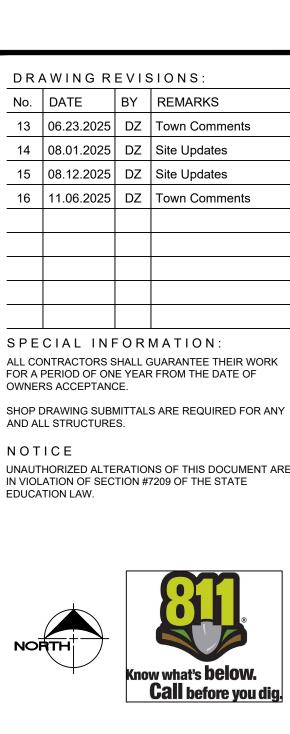

CONSULTANT

JAMES ALLEN RUMSEY

570 DELAWARE AVE., BUFFALO, NY 14202

(716) 886-0211

SEAL


COVER


SHEET

DRAWING NO.

11.16.2023

TIONS

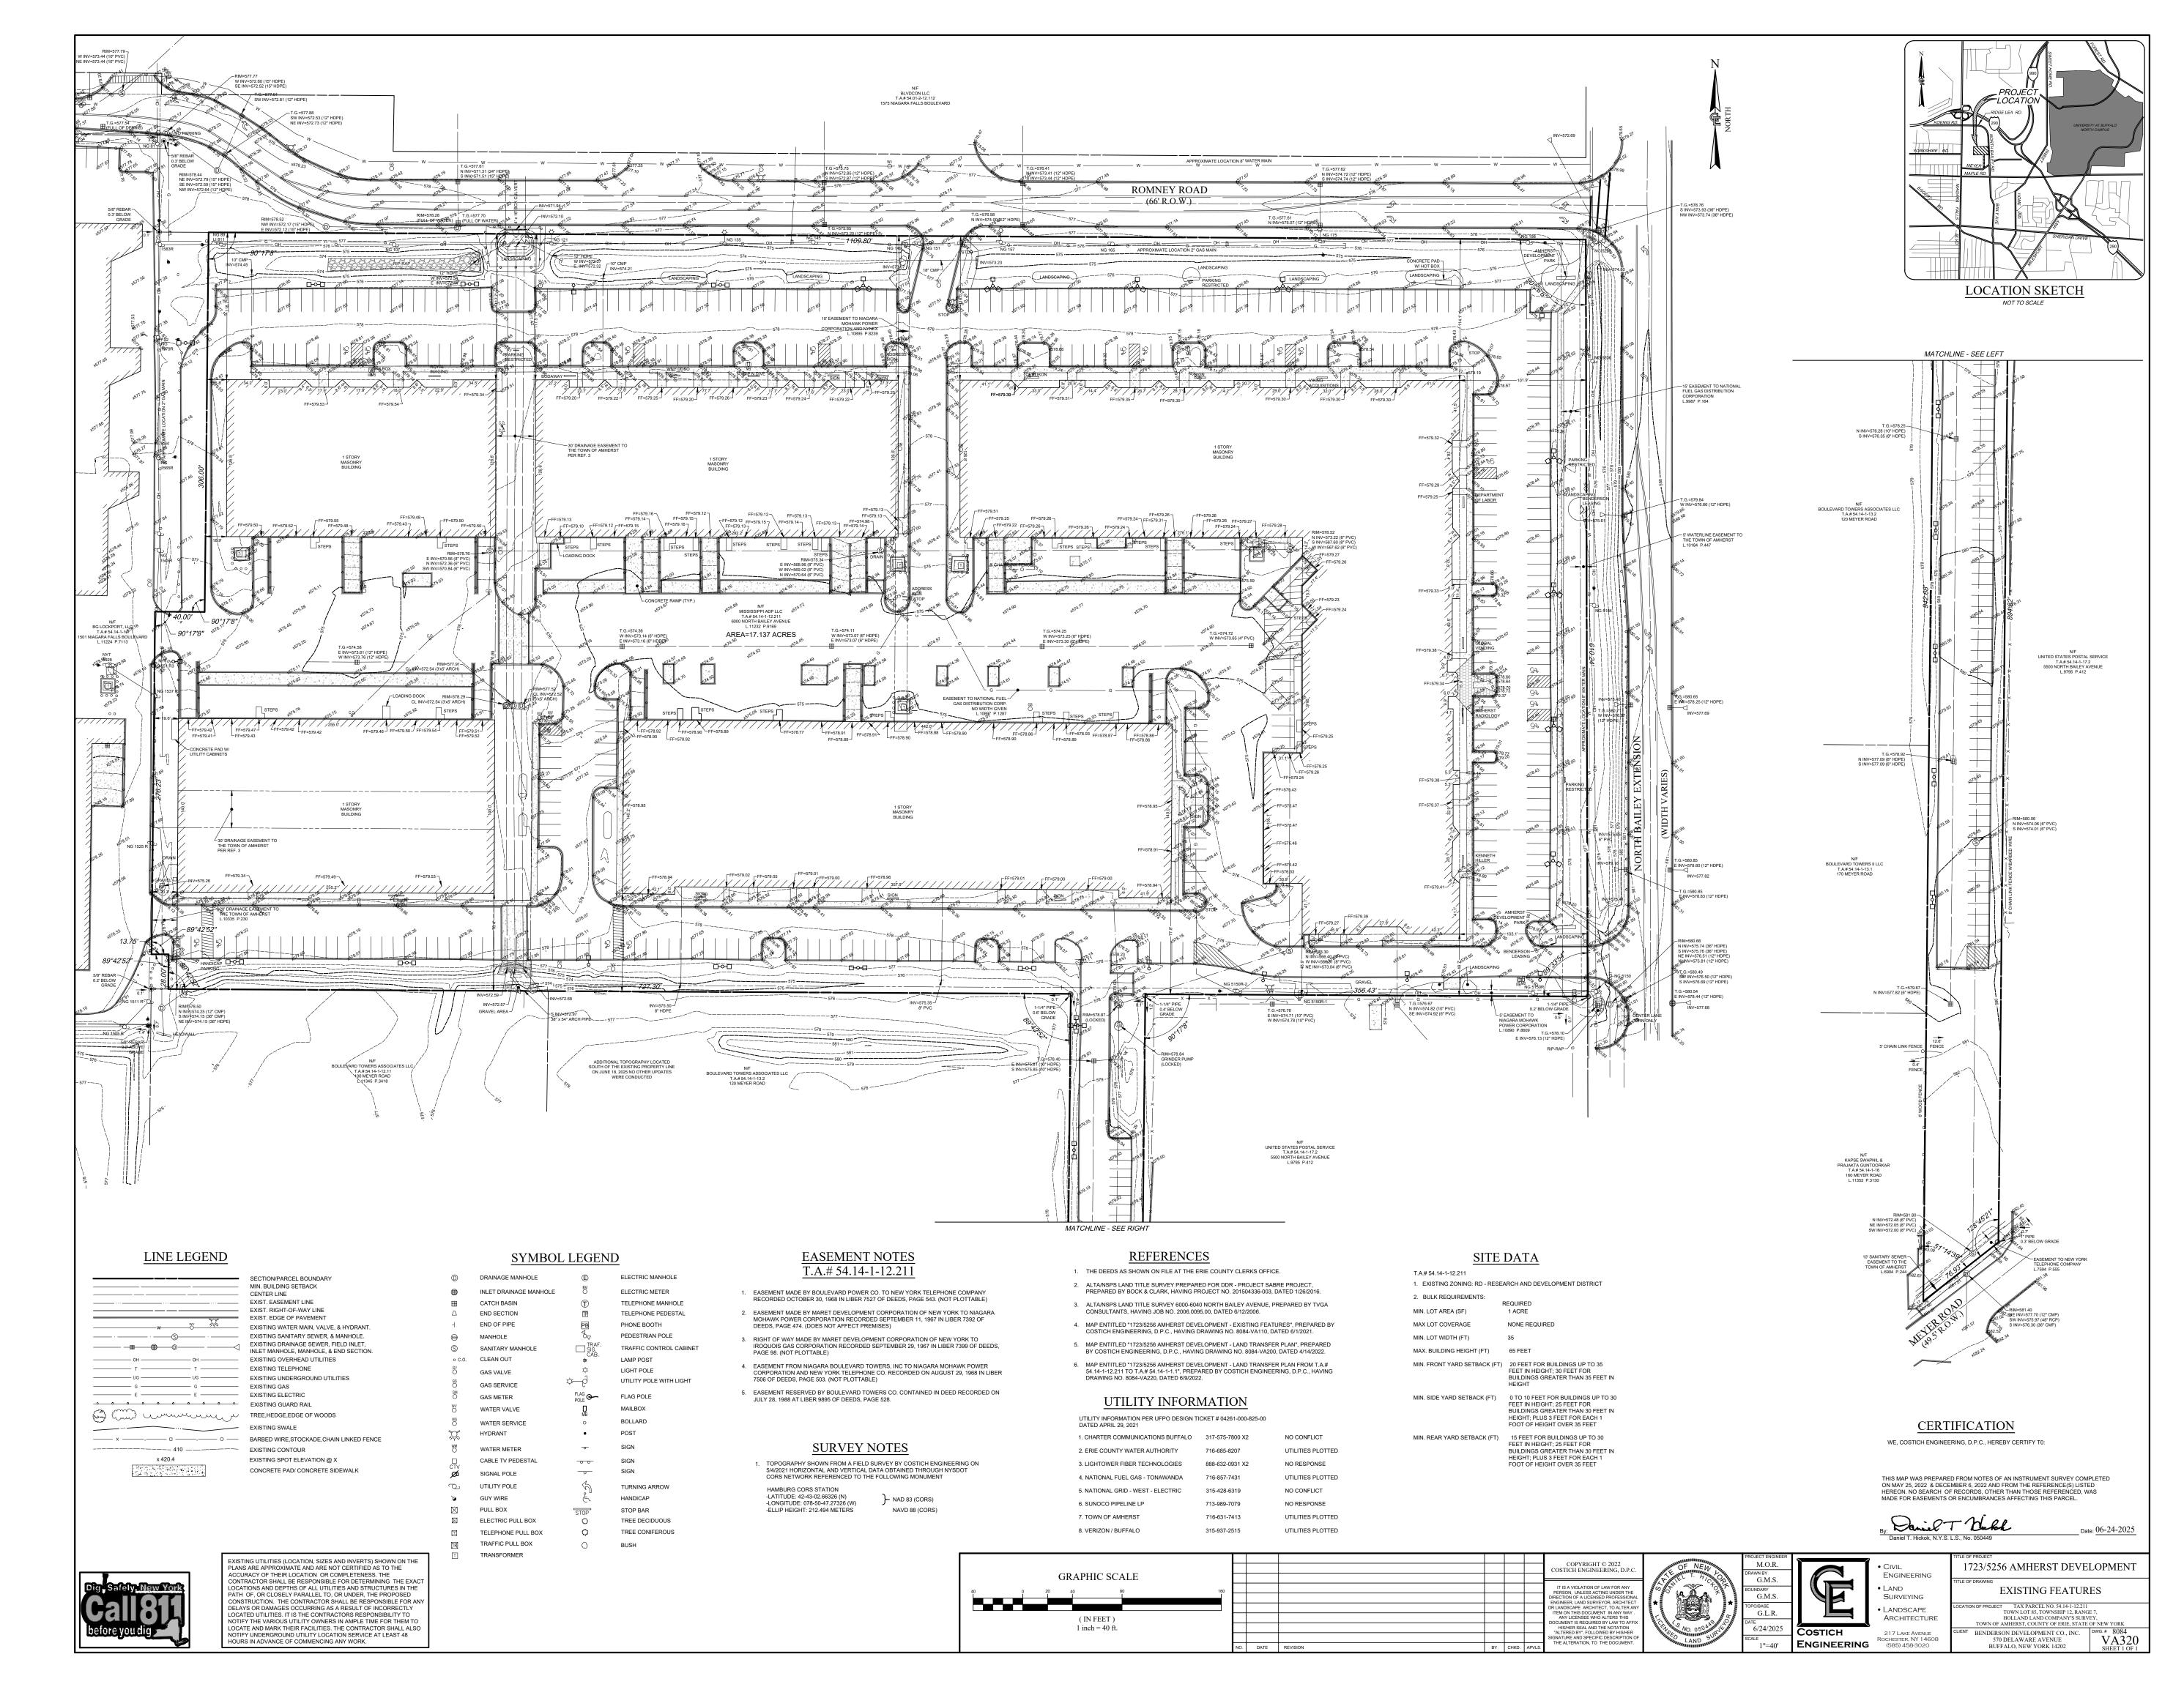

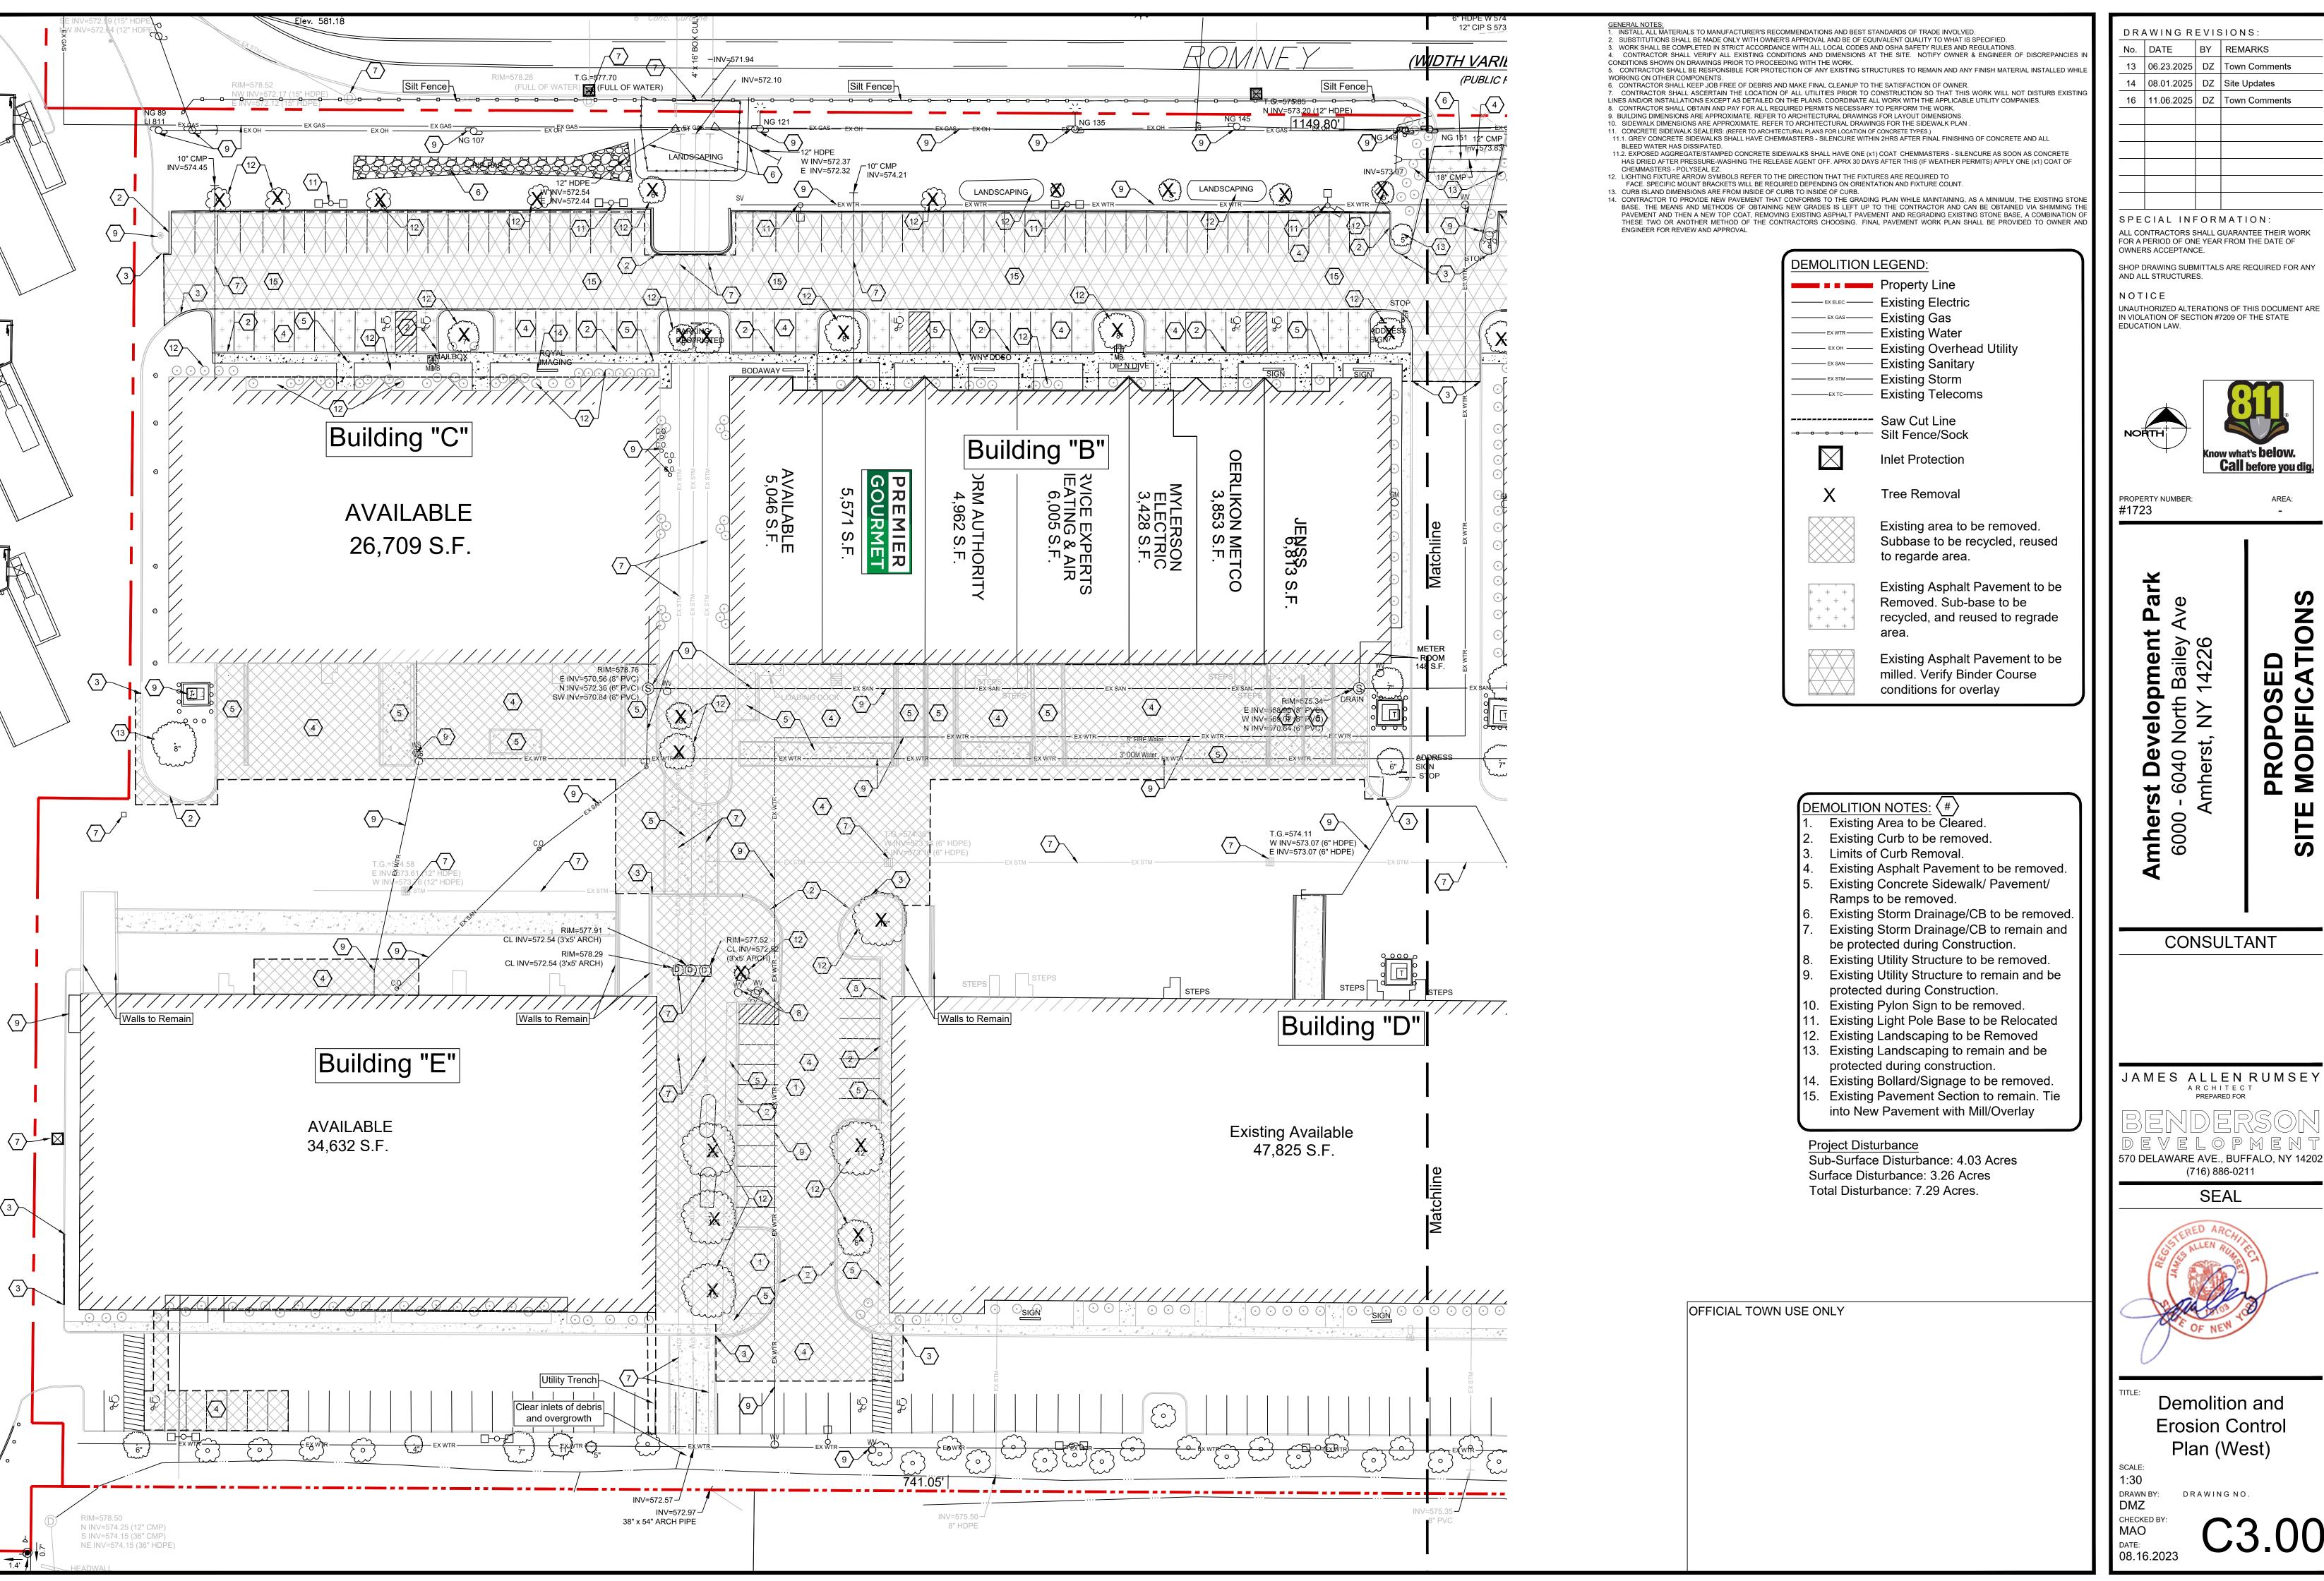

BY REMARKS 13 | 06.23.2025 | DZ | Town Comments 14 08.01.2025 DZ Site Updates 16 | 11.06.2025 | DZ | Town Comments

> SPECIAL INFORMATION: ALL CONTRACTORS SHALL GUARANTEE THEIR WORK

SHOP DRAWING SUBMITTALS ARE REQUIRED FOR ANY

UNAUTHORIZED ALTERATIONS OF THIS DOCUMENT ARE IN VIOLATION OF SECTION #7209 OF THE STATE





AREA:

PROPOSED MODIFICATIONS



Demolition and **Erosion Control** Plan (West)

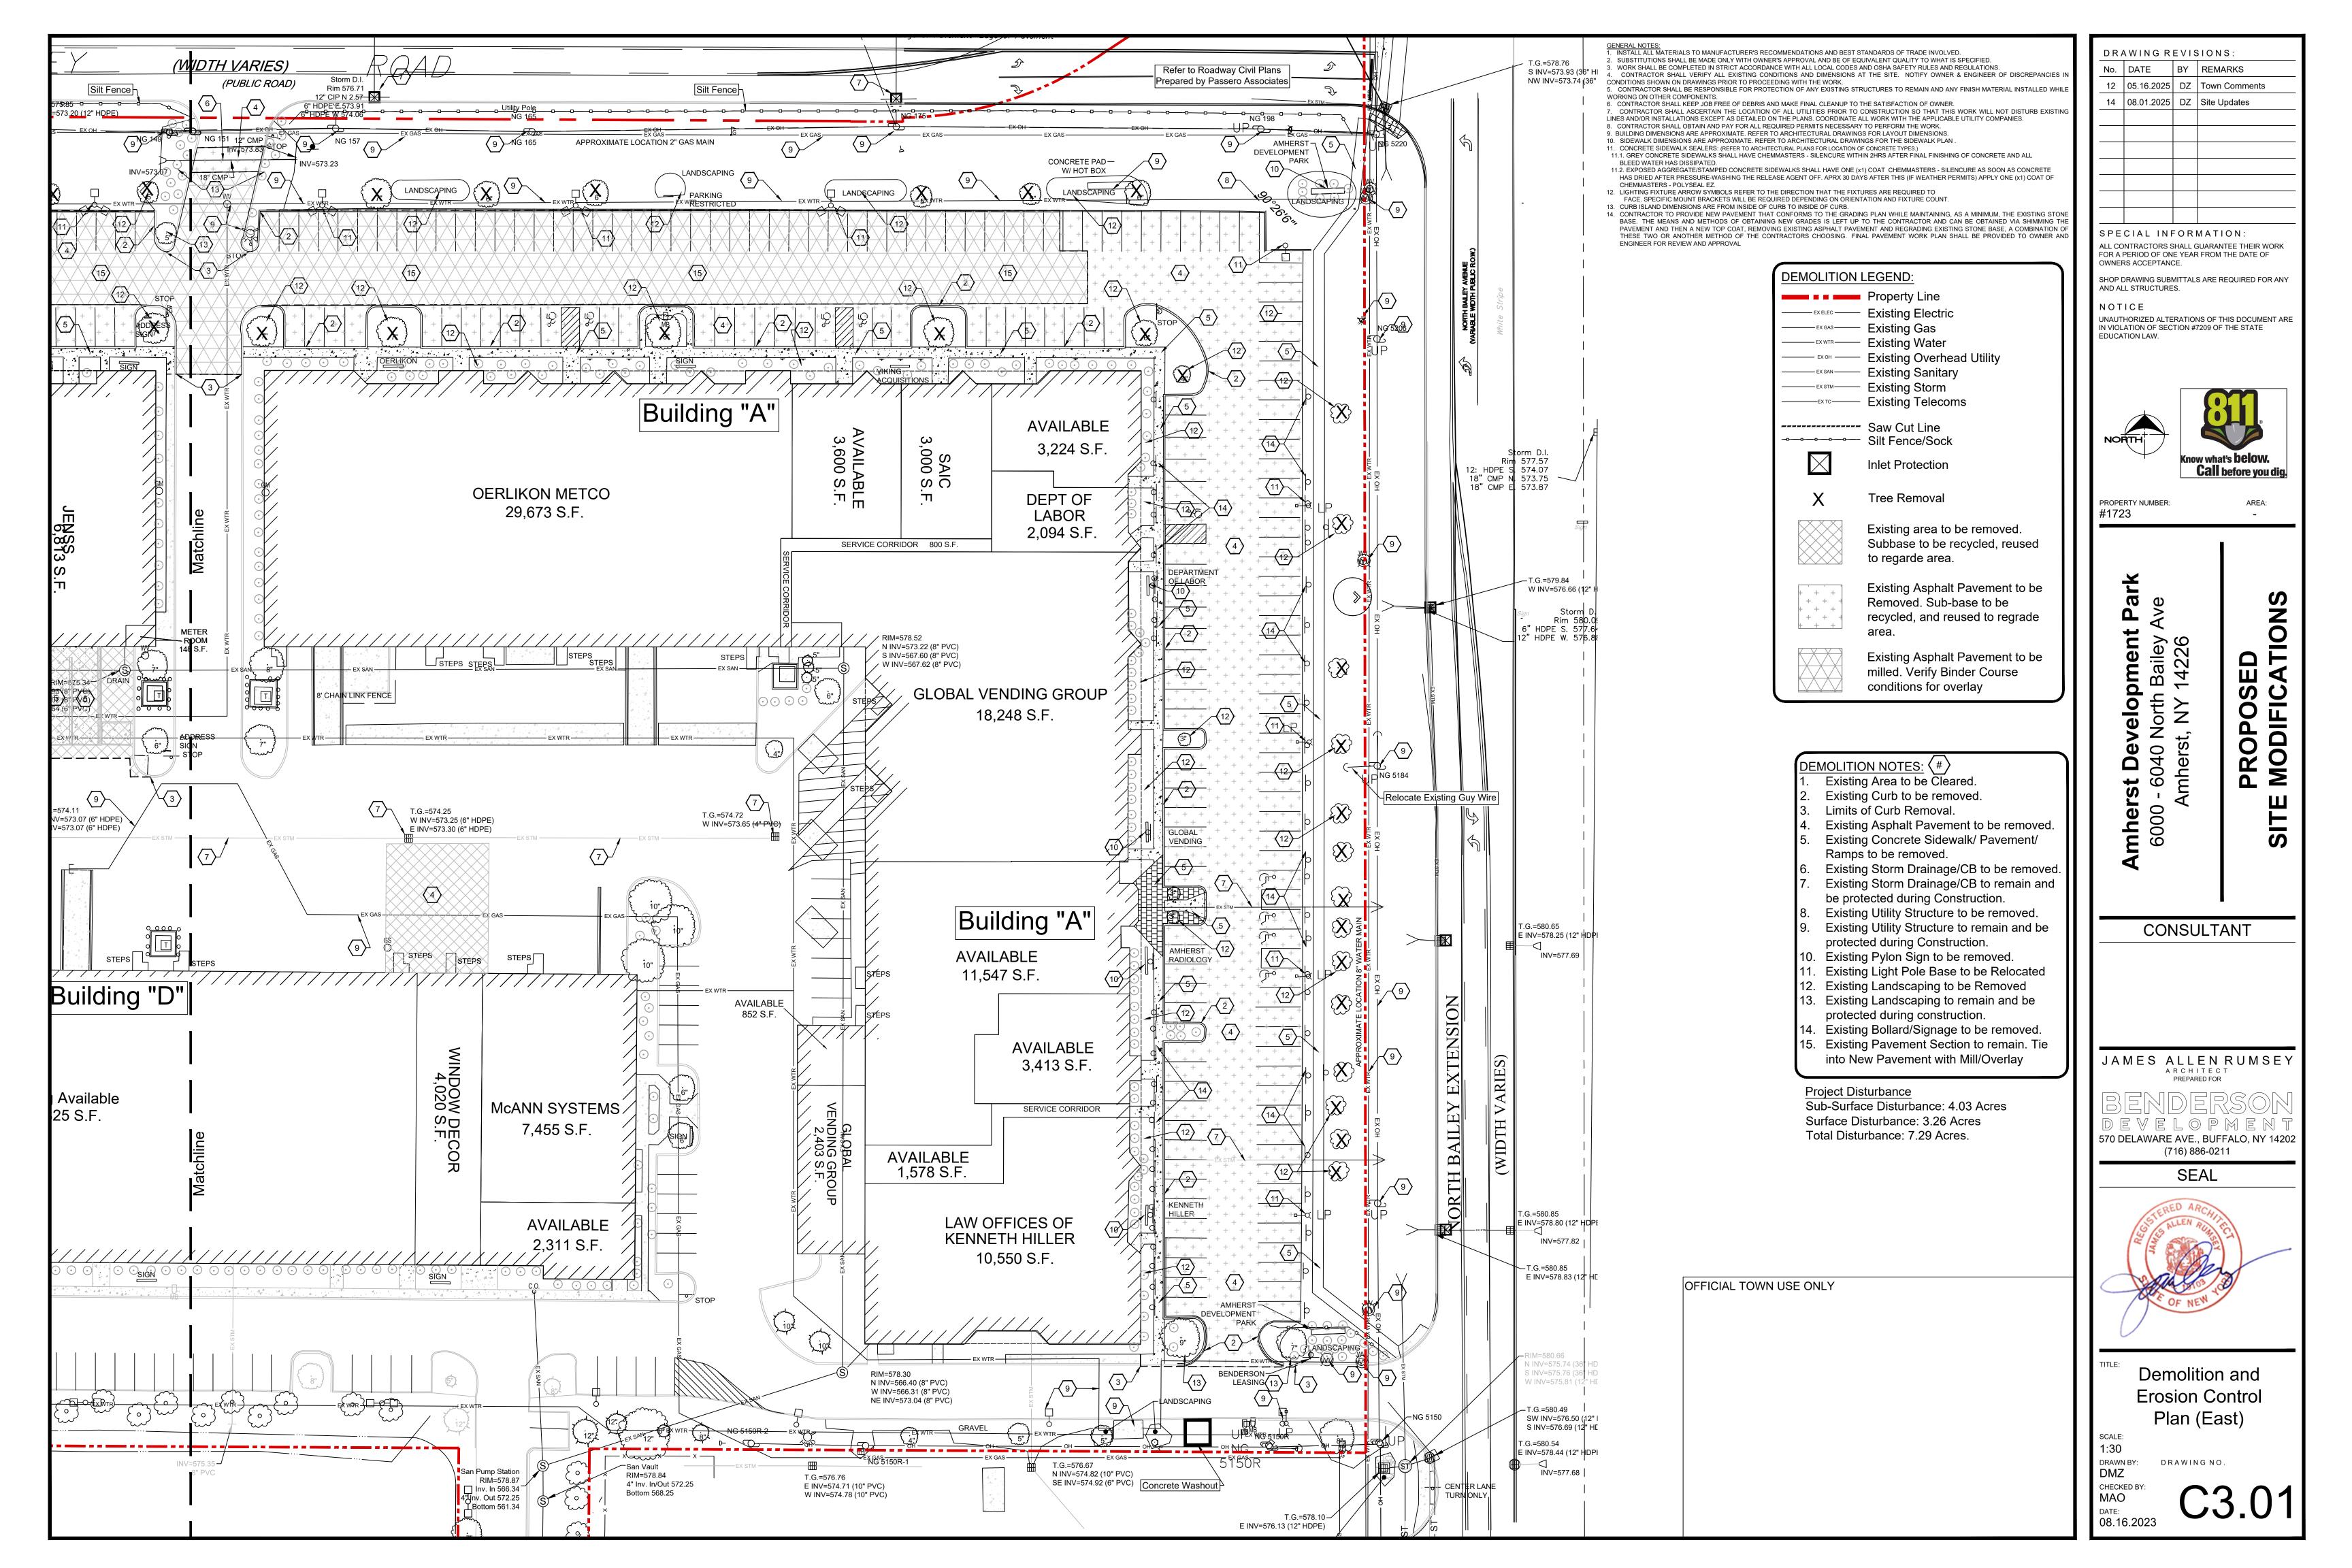

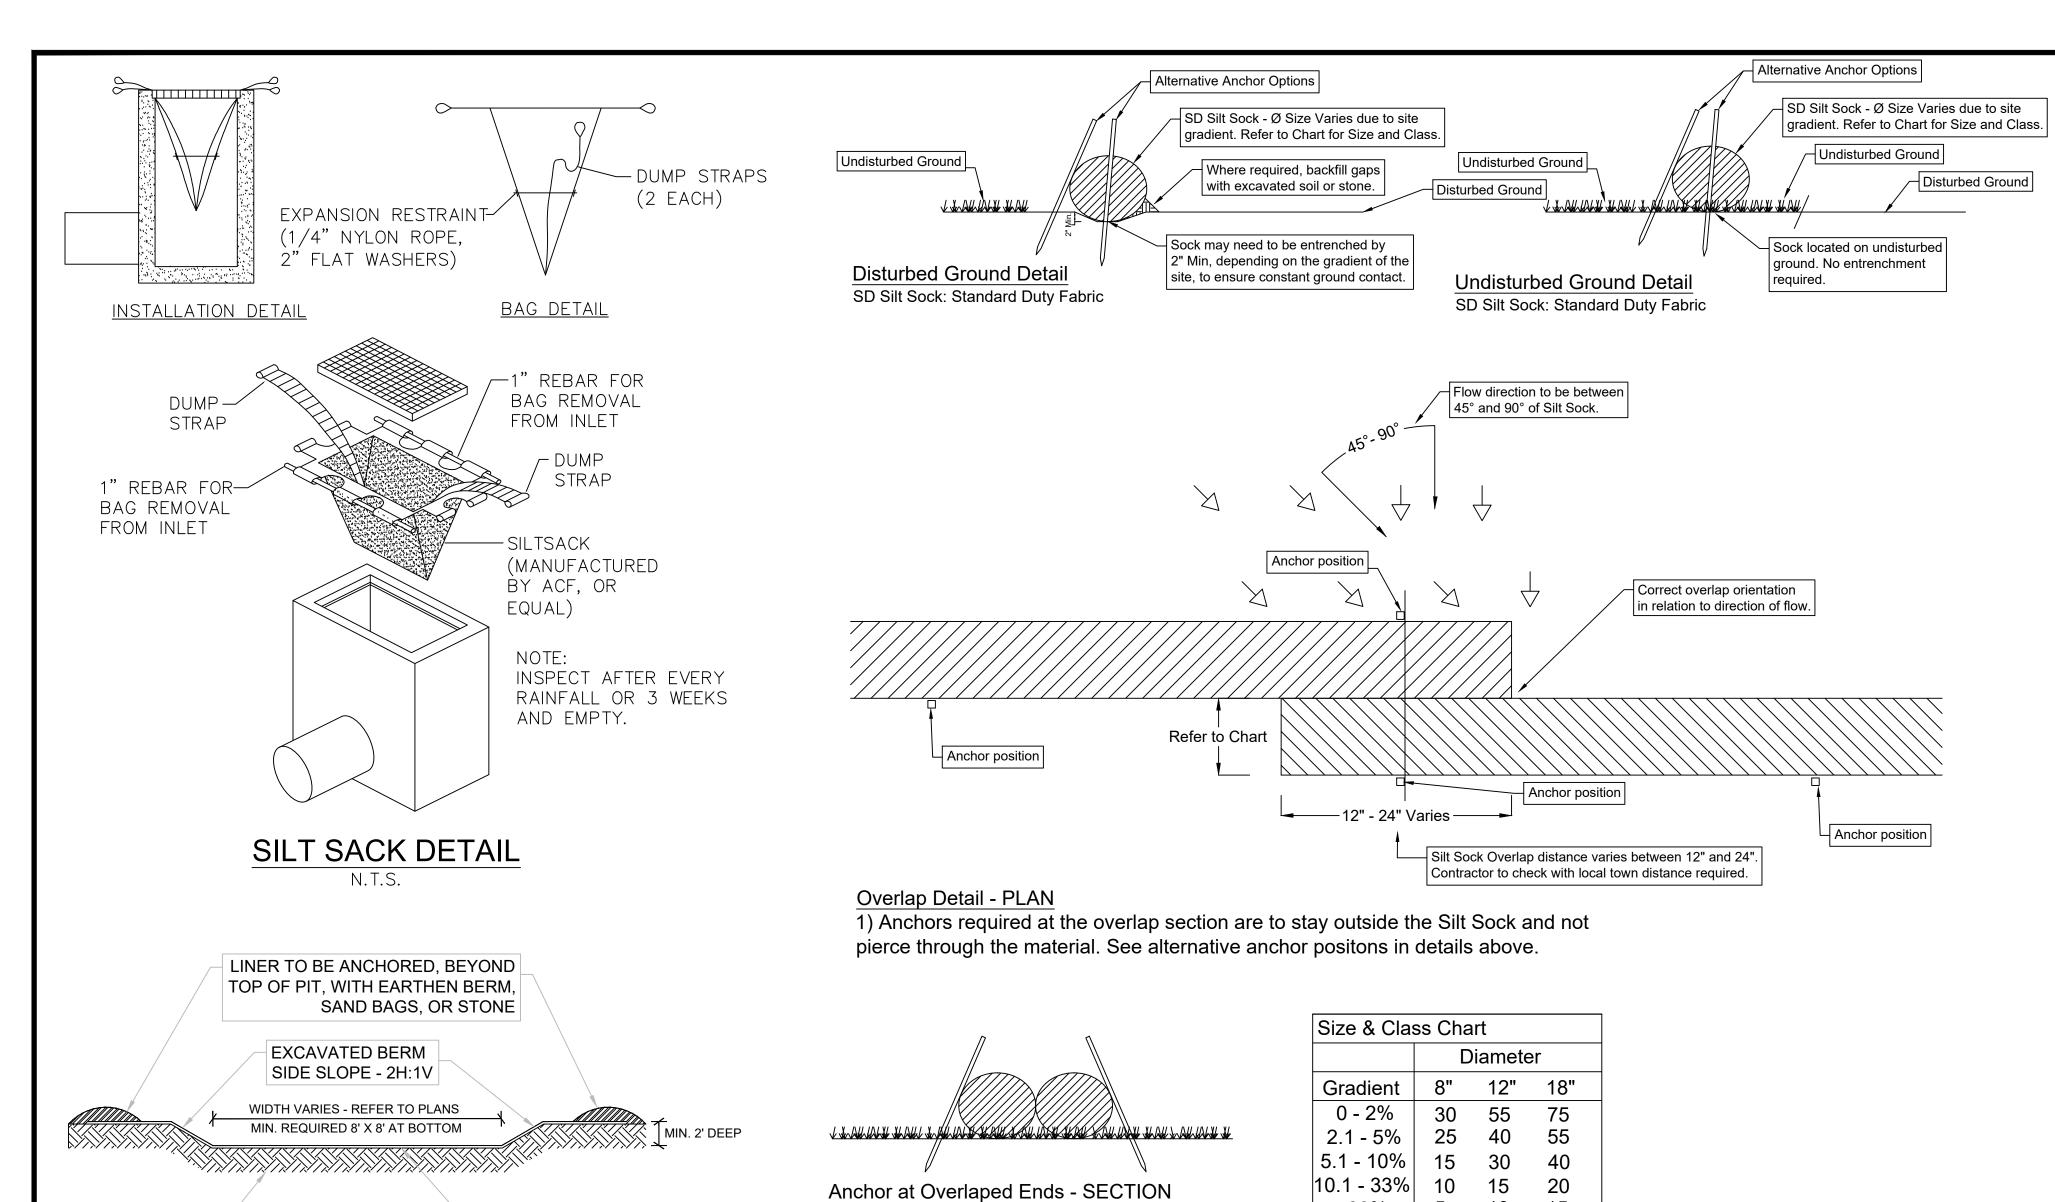

EXISTING

SUBGRADE

PROPOSED PLASTIC OR

THICKNESS OF 10 MILS

TYPICAL CONCRETE WASH OUT DETAIL

1. CONSTRUCT TO 2016 NYSDEC BLUE BOOK DESIGN CRITERIA

POLYETHYLENE SHEET WITH MIN.

SD SILT SOCK DETAIL SD Silt Sock: Standard Duty Fabric

> 33% 5 10 15

Notes:

1 - Do not use sock below the normal watermark or perpendicular to flow in river and where the maximum incline is greater than 50%.

2 - Contractors should be aware of federal, state and local laws, rules regulations or permit requirements for the use of Silt Socks on site.

3 - Sock should be positioned on the outline of the area to be protected, but must be installed between 45° to 90° from directions of flow.

4 - Sock may be required to be entrenched a minimum of 2" on disturbed ground to ensure constant ground contact.

5 - All gaps and ruts must be backfilled with soil or sock material.

6 - Sock overlap should be in the direction of the flow. Overlap amount will be between 12" and 24". Contractor to check with local town for requirements.

7 - If sediment collects to 1/2 the height of the sock, then a second sock may be stacked immediately up slope of the original instead of removing the sediment.

8 - Sock joint is where two sock sections meet on a level grade, overlap and adjoining ends, tightening the ends together, and anchoring through each end. Where two sections meet on un-level ground, j-hook higher elevated end, anchor, and begin new section just below.

Back fill any gaps. 9 - Sock should be inspected and repaired as needed.

10 - If ruts begin under the sock they should be backfilled with soil and compacted so that the ground and sock have continuous contact.

11 - If sock rolls out of place, the sock should be repositioned and secured with additional

12 - Tears in the Sock fabric may be repaired by wrapping a new piece of fabric over the sock and securing, or by place a second sock immediately up slope with the required overlap beyond deformation.

13 - A section of sock should be replaced whenever it has weakened to such an extent that the efficiency is reduced or diminished. Weakening can occur because the natural mesh

fabric breaks down over time of from being moved/dragged on site. 14 - Sock should be replaced when sediment has built up and has been removed three

15 - All sediment in disturbed area next to sock must be removed and correctly disposed of before the sock can be removed.

16 - When removing, cut sock open and spread the filler material around. The netting should be removed from site.

17 - Sock should be installed before works commence on site.

DRAWING REVISIONS: No. DATE BY REMARKS 08.30.2024 DZ Town Comments

SPECIAL INFORMATION: ALL CONTRACTORS SHALL GUARANTEE THEIR WORK

FOR A PERIOD OF ONE YEAR FROM THE DATE OF

OWNERS ACCEPTANCE.

SHOP DRAWING SUBMITTALS ARE REQUIRED FOR ANY AND ALL STRUCTURES.

UNAUTHORIZED ALTERATIONS OF THIS DOCUMENT ARE IN VIOLATION OF SECTION #7209 OF THE STATE





AREA:

PROPERTY NUMBER: #1723

velopment | North Bailey A st, NY 14226

0

mhe

DATIONS PROPOSE MODIFICA

rst Deve) - 6040 No Amherst, l


CONSULTANT

JAMES ALLEN RUMSEY

570 DELAWARE AVE., BUFFALO, NY 14202

SEAL

(716) 886-0211

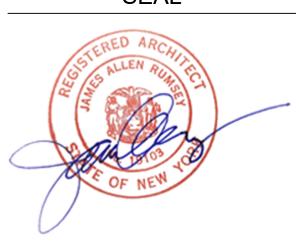

Demolition and **Erosion Control Details**

DRAWING NO. DMZ

DATE: 08.16.2023

OFFICIAL TOWN USE ONLY

₹- D	R-D
_	
AC	17.14 AC
65'	<30'
	_
40'	102.3'
15'	16.7'
15'	48.4'
 25'	0.3'
	*0'
10'	8.5'
-	

- Setback variance previously granted along North Bailey Road License Agreement along North Bailey has been previously granted Romney Road Pavement/Parking Setback 14.5'

- N. Bailey Pavement/Parking Setback 11.7'

PROPOSED	PARKING A	ANAYLSIS		•
USE	CODE	S.F. USAGE	REQUIRED	PROVIDED
WAREHOUSE	1 / 1000 G.S.F	197,020 GSF	197 Spaces	
OFFICE	1 / 200 N.S.F.	Bld A - 12,644 GSF * .85 = 10,748 NSF Bld B - 42,292 GSF * .80 = 33,834 NSF Bld C - 26,709 GSF * .90 = 24,038 NSF Total: 68,620 NSF	343 Spaces	
TOTAL			540 Spaces	514 Spaces*
STALL SIZE			9' X 19'	9' X 19'
•				


*Refer alternative parking study for site required parking

Single Story, Single Tenant = 90% GSF Net Square Footage: Multistory, Single Tenant = 80% GSF

Single Story, Multiple tenants = 85% GSF

LANDSCAPE	E ANALYSIS - BUILDIN	NG LANDSCAPING	
AREA	CODE	REQUIRED	PROVIDED
BUILDING A	§203-7-2-3 a (3) (e) Building landscaping	850LF * 3' = 2,550 S.F.	3,800 S.F. BUILDING LANDSCAPING
BUILDING B	to have a "Minimum Average width of 3 feet"	292LF * 3' = 876 S.F.	1,115 S.F. BUILDING LANDSCAPING
BUILDING C	Building Frontage * 3'	218LF * 3' = 654 S.F.	685 S.F. BUILDING LANDSCAPING

LANDSCAPE	ANALYSIS - INTERIO	OR LANDSCAPING	
AREA	CODE	REQUIRED	PROVIDED
INTERIOR PARKING AREA	§203-7-2-3 A (3) (a) 10% of parking area	SITE PARKING AREA = 8.54 ACRES 10% = 0.85 ACRES = 37,225 S.F.	TOTAL INTERIOR LANDSCAPING 40,450 S.F. = 10.9%

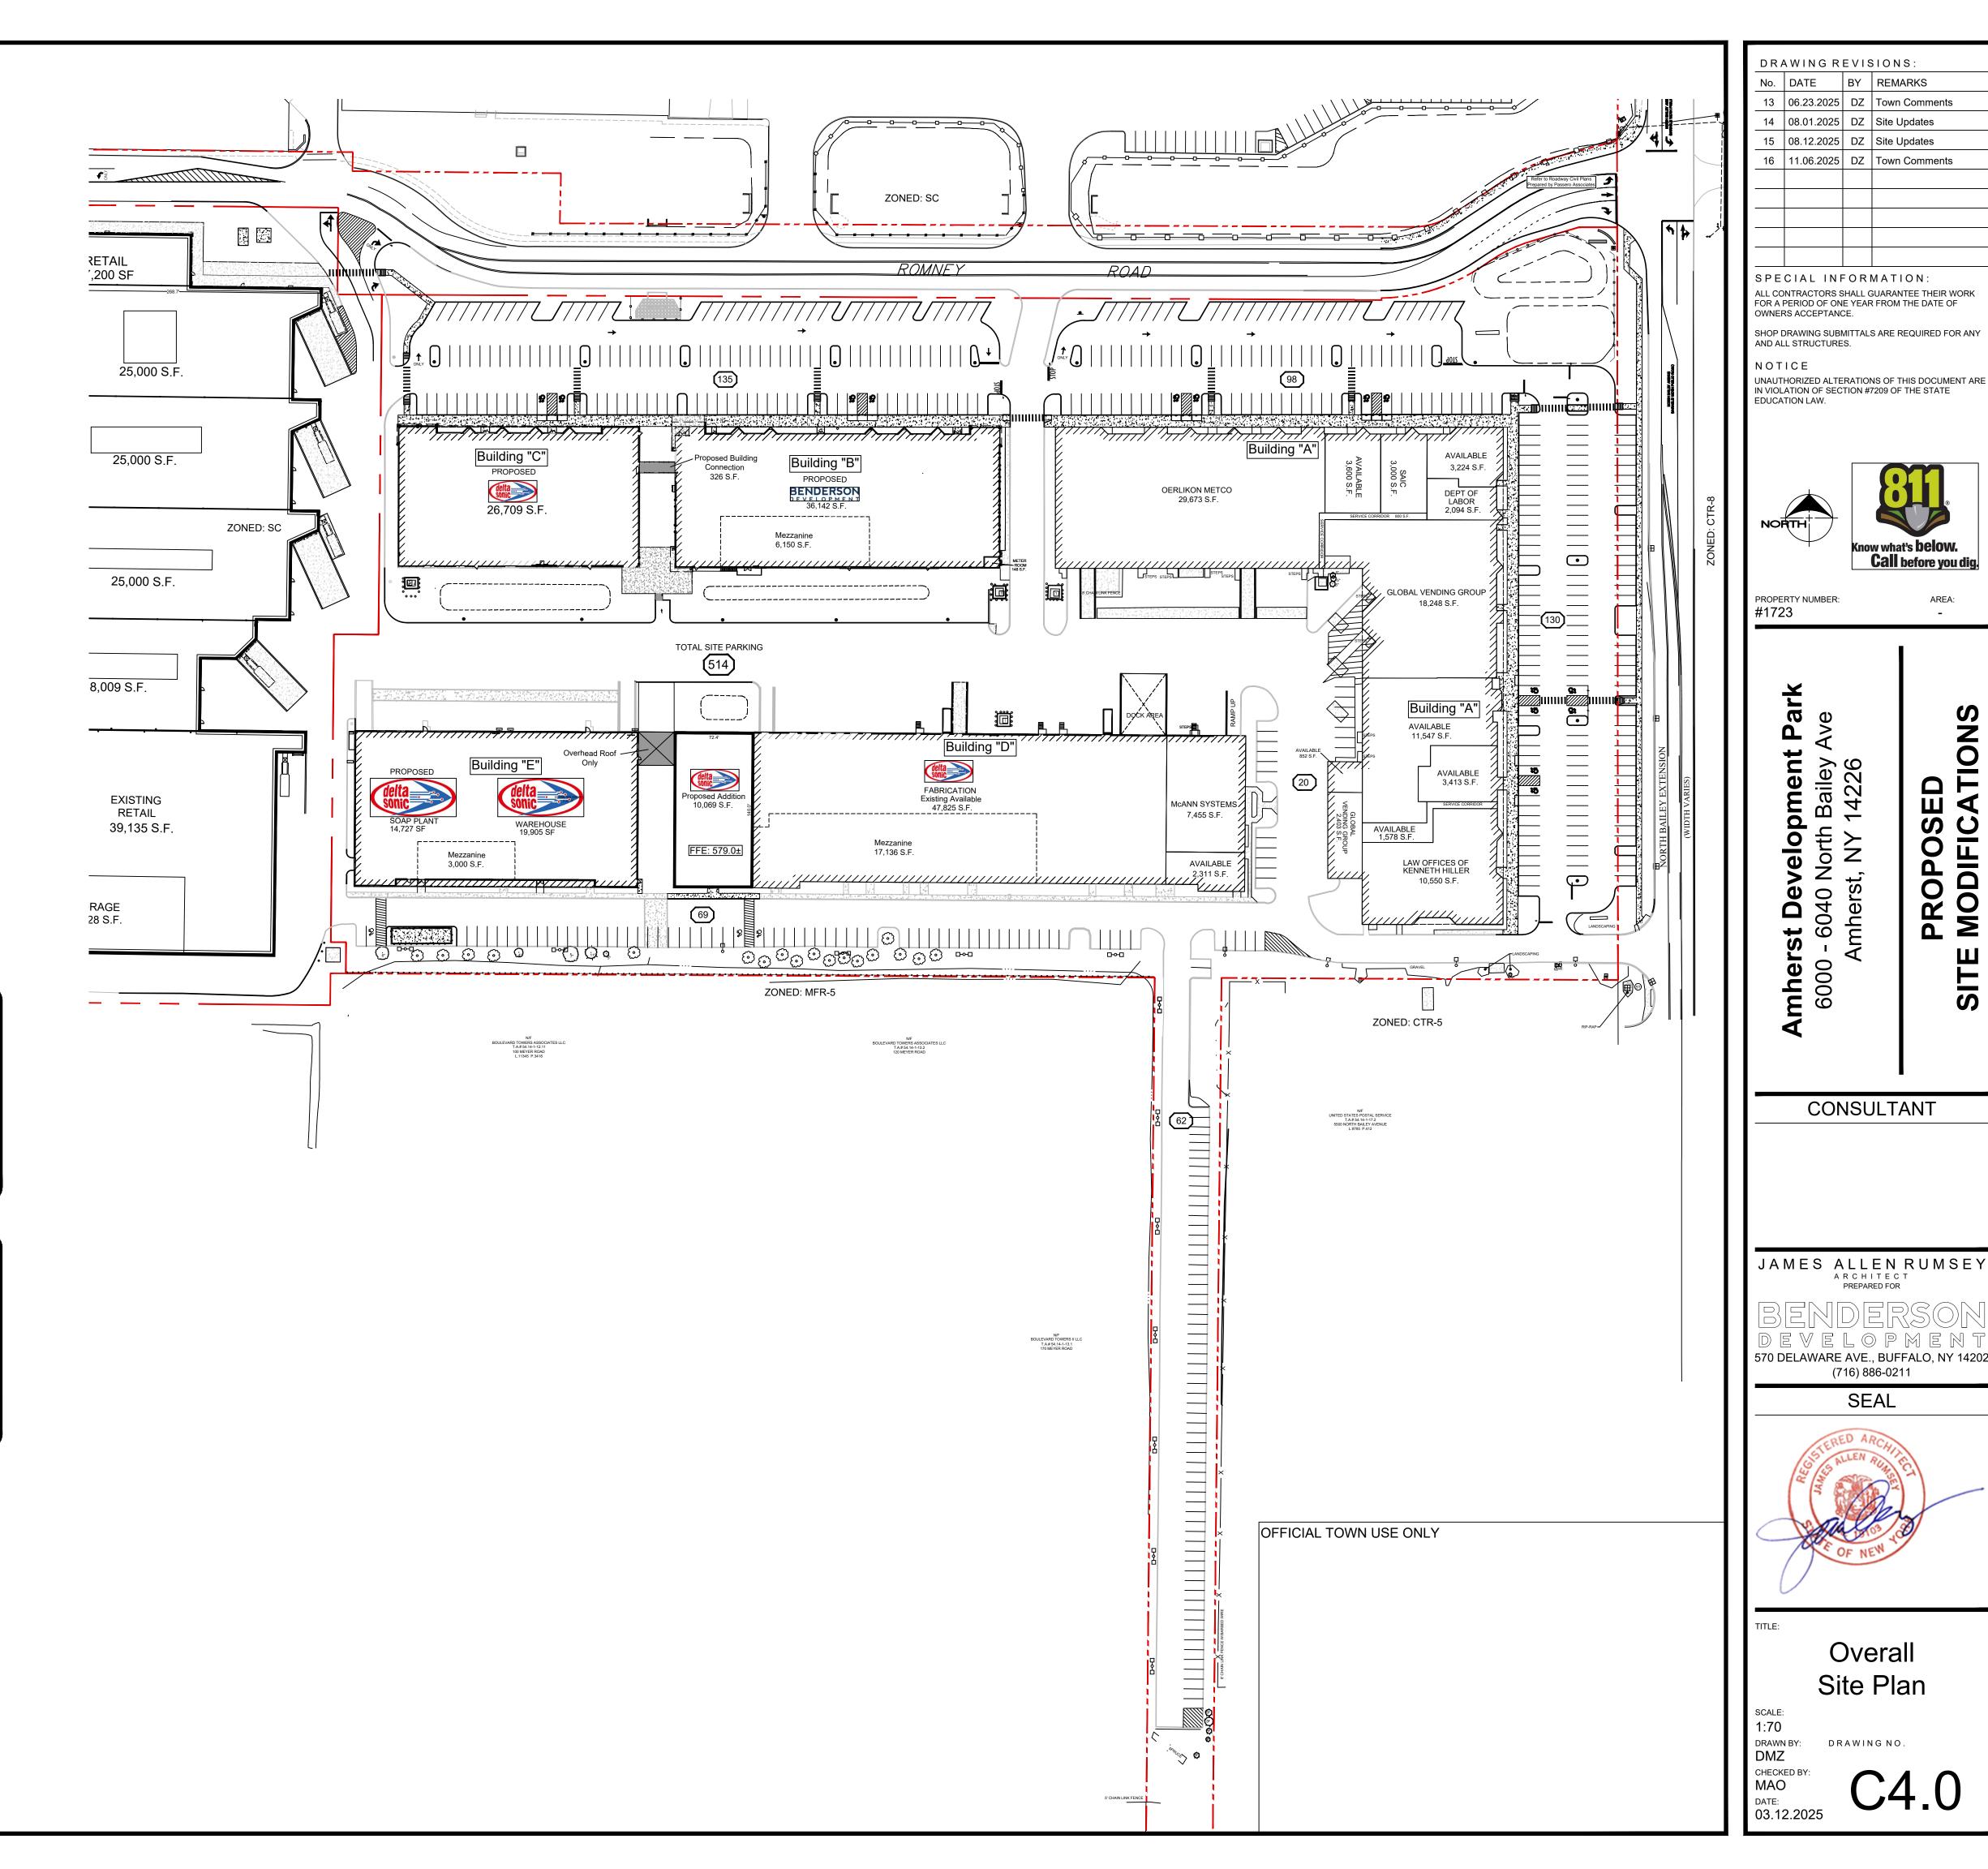

Know what's **below. Call** before you dig.

AREA:

PROPOSED MODIFICATIONS

S

0


CONSULTANT


(716) 886-0211


SEAL


Overall


Site Plan

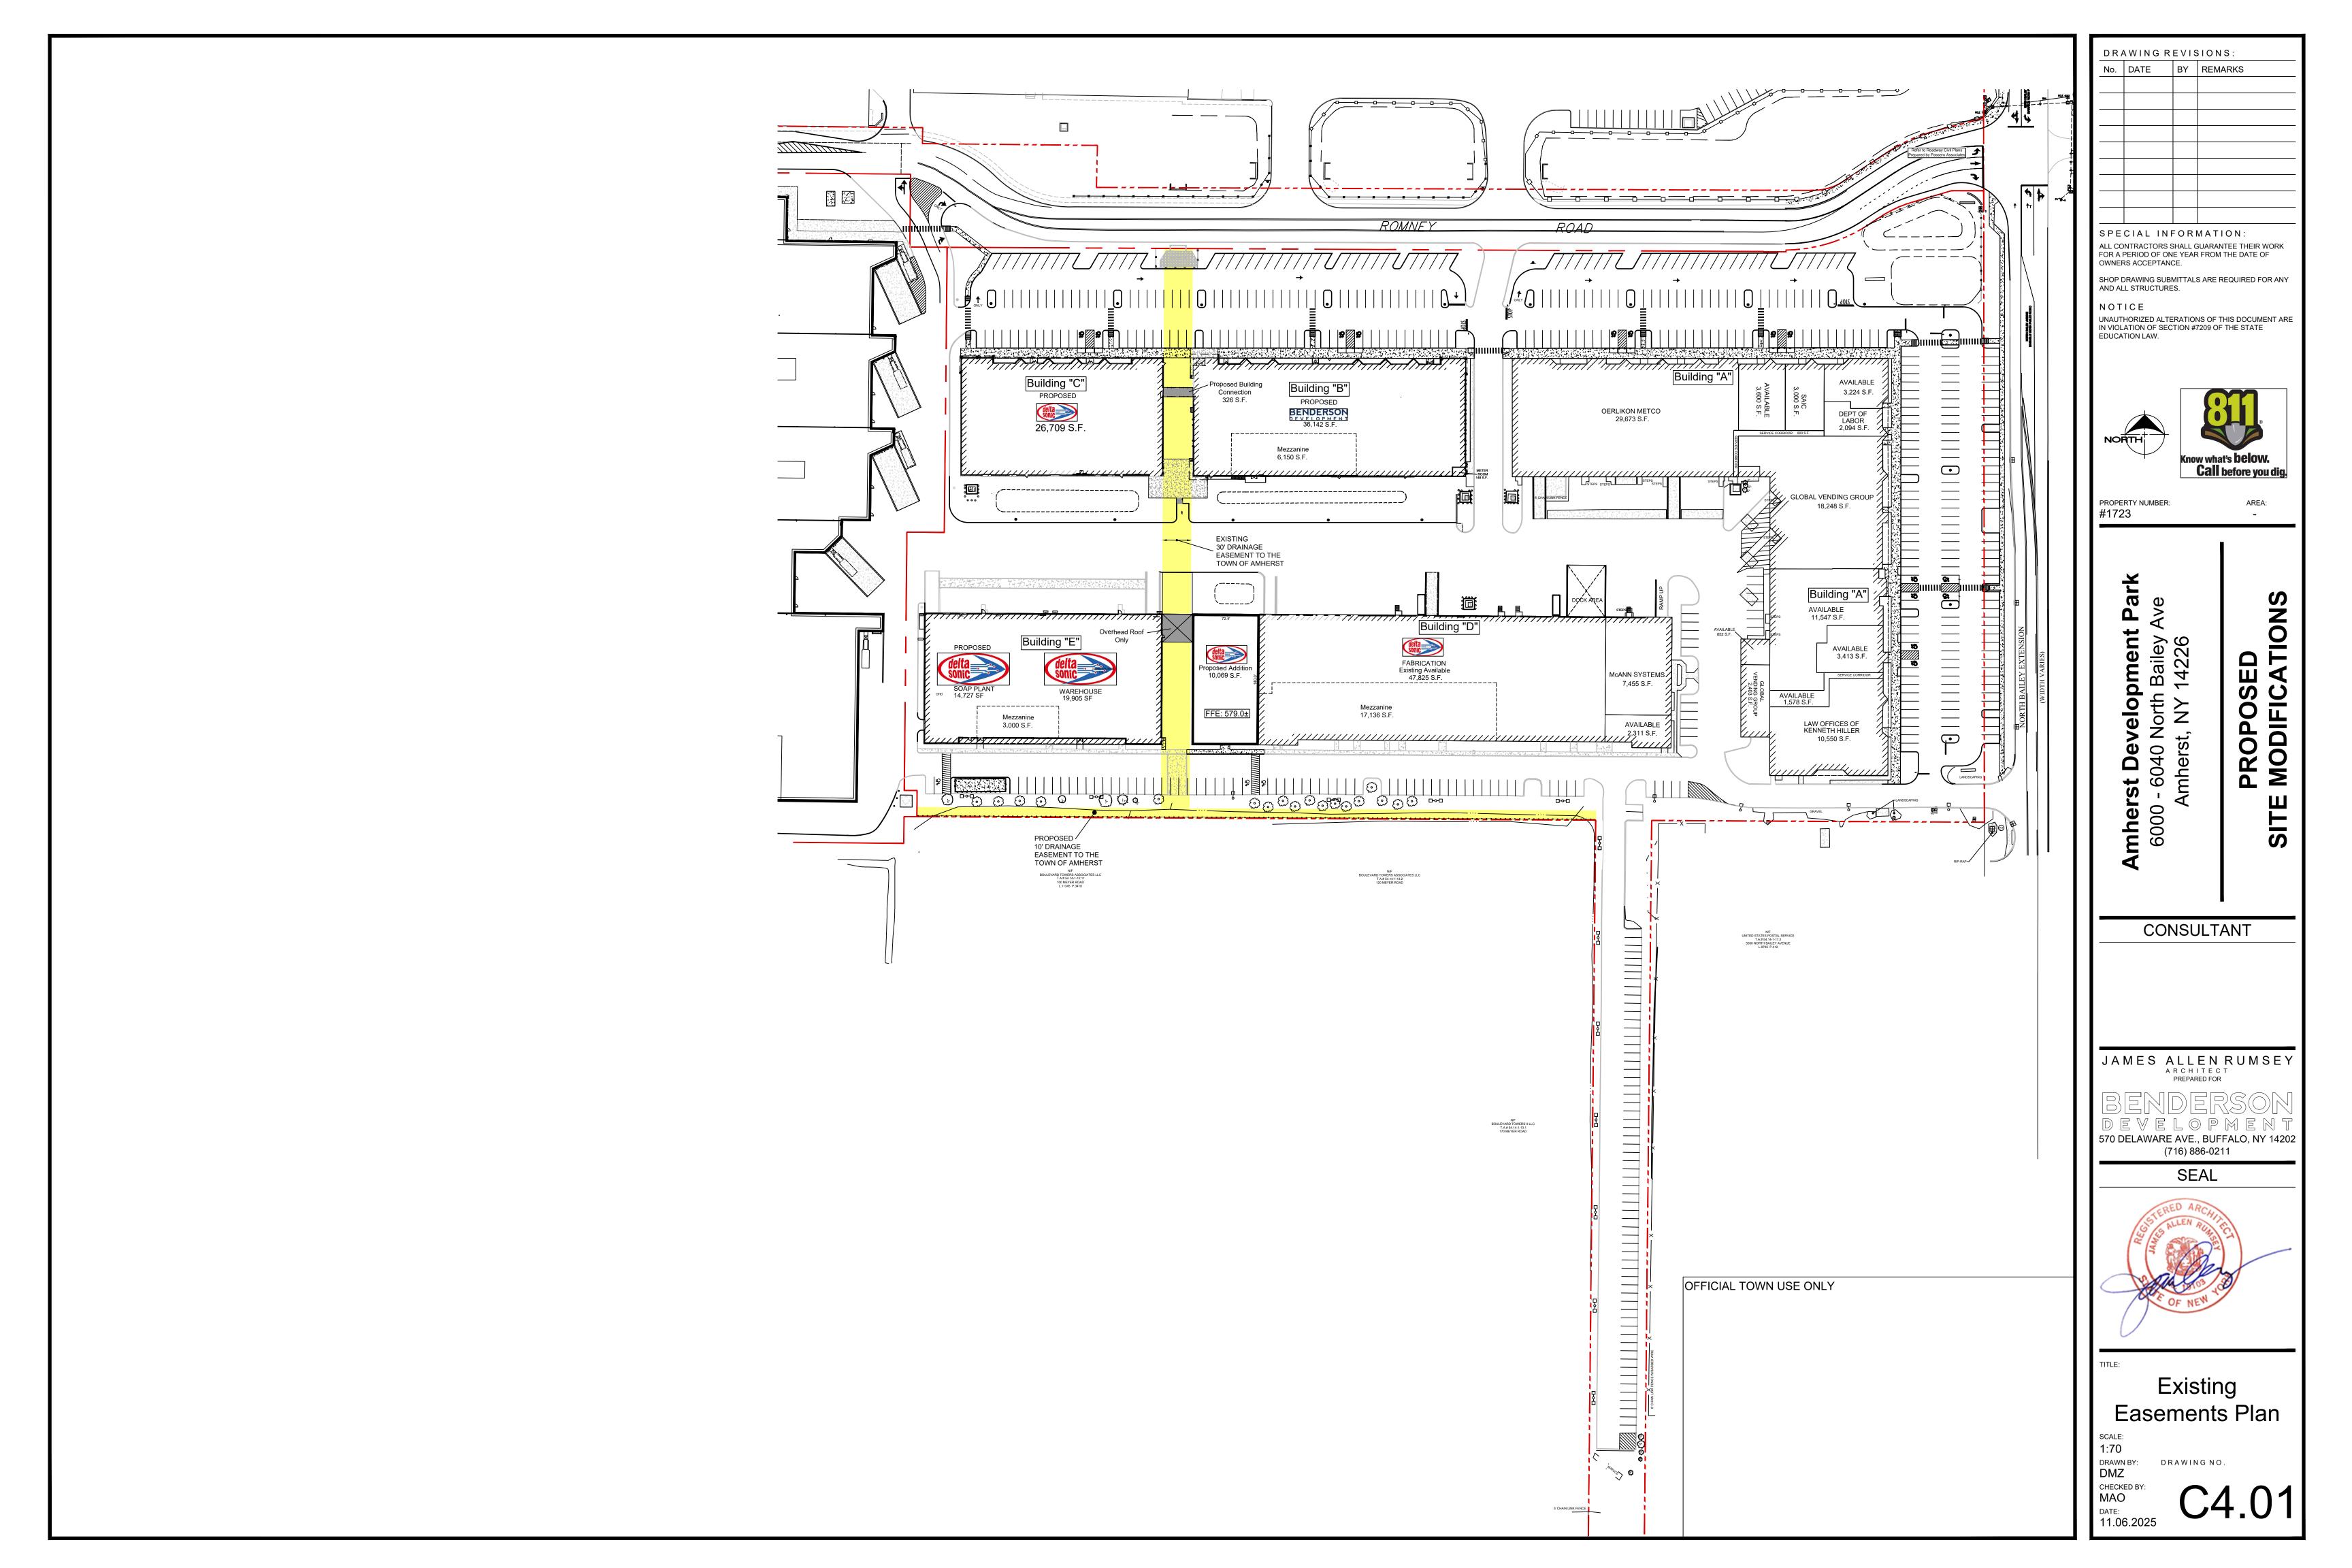


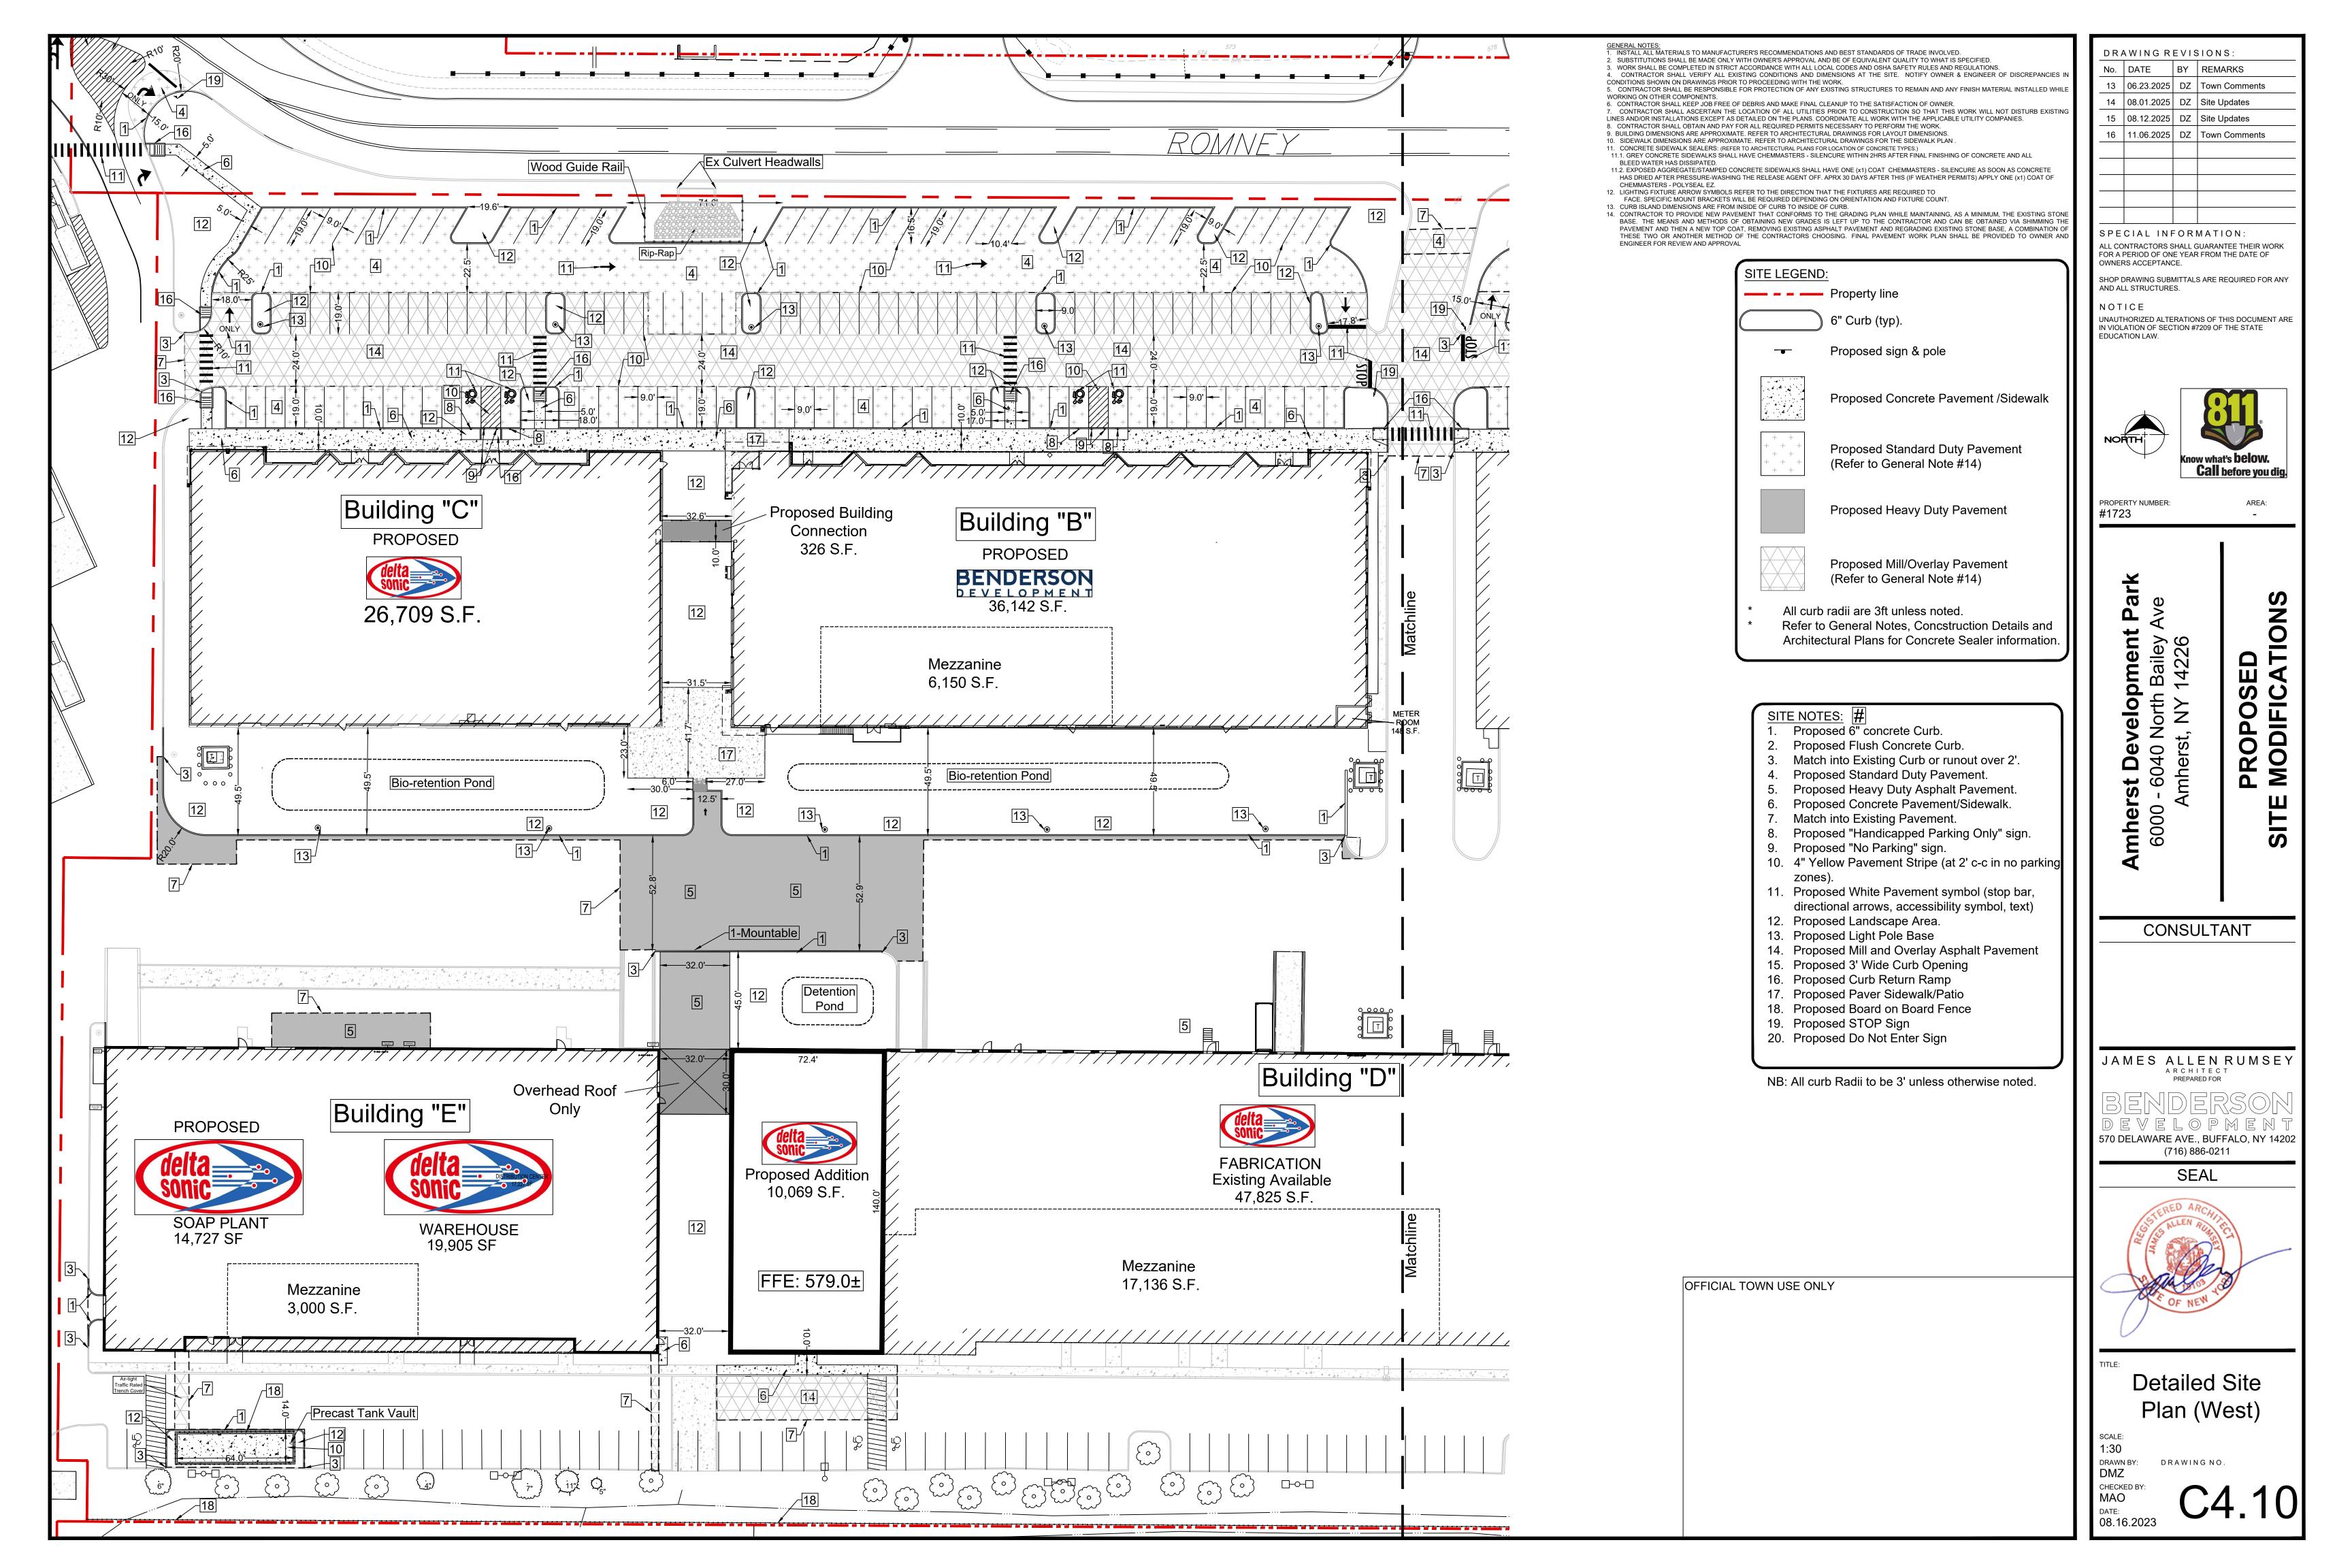

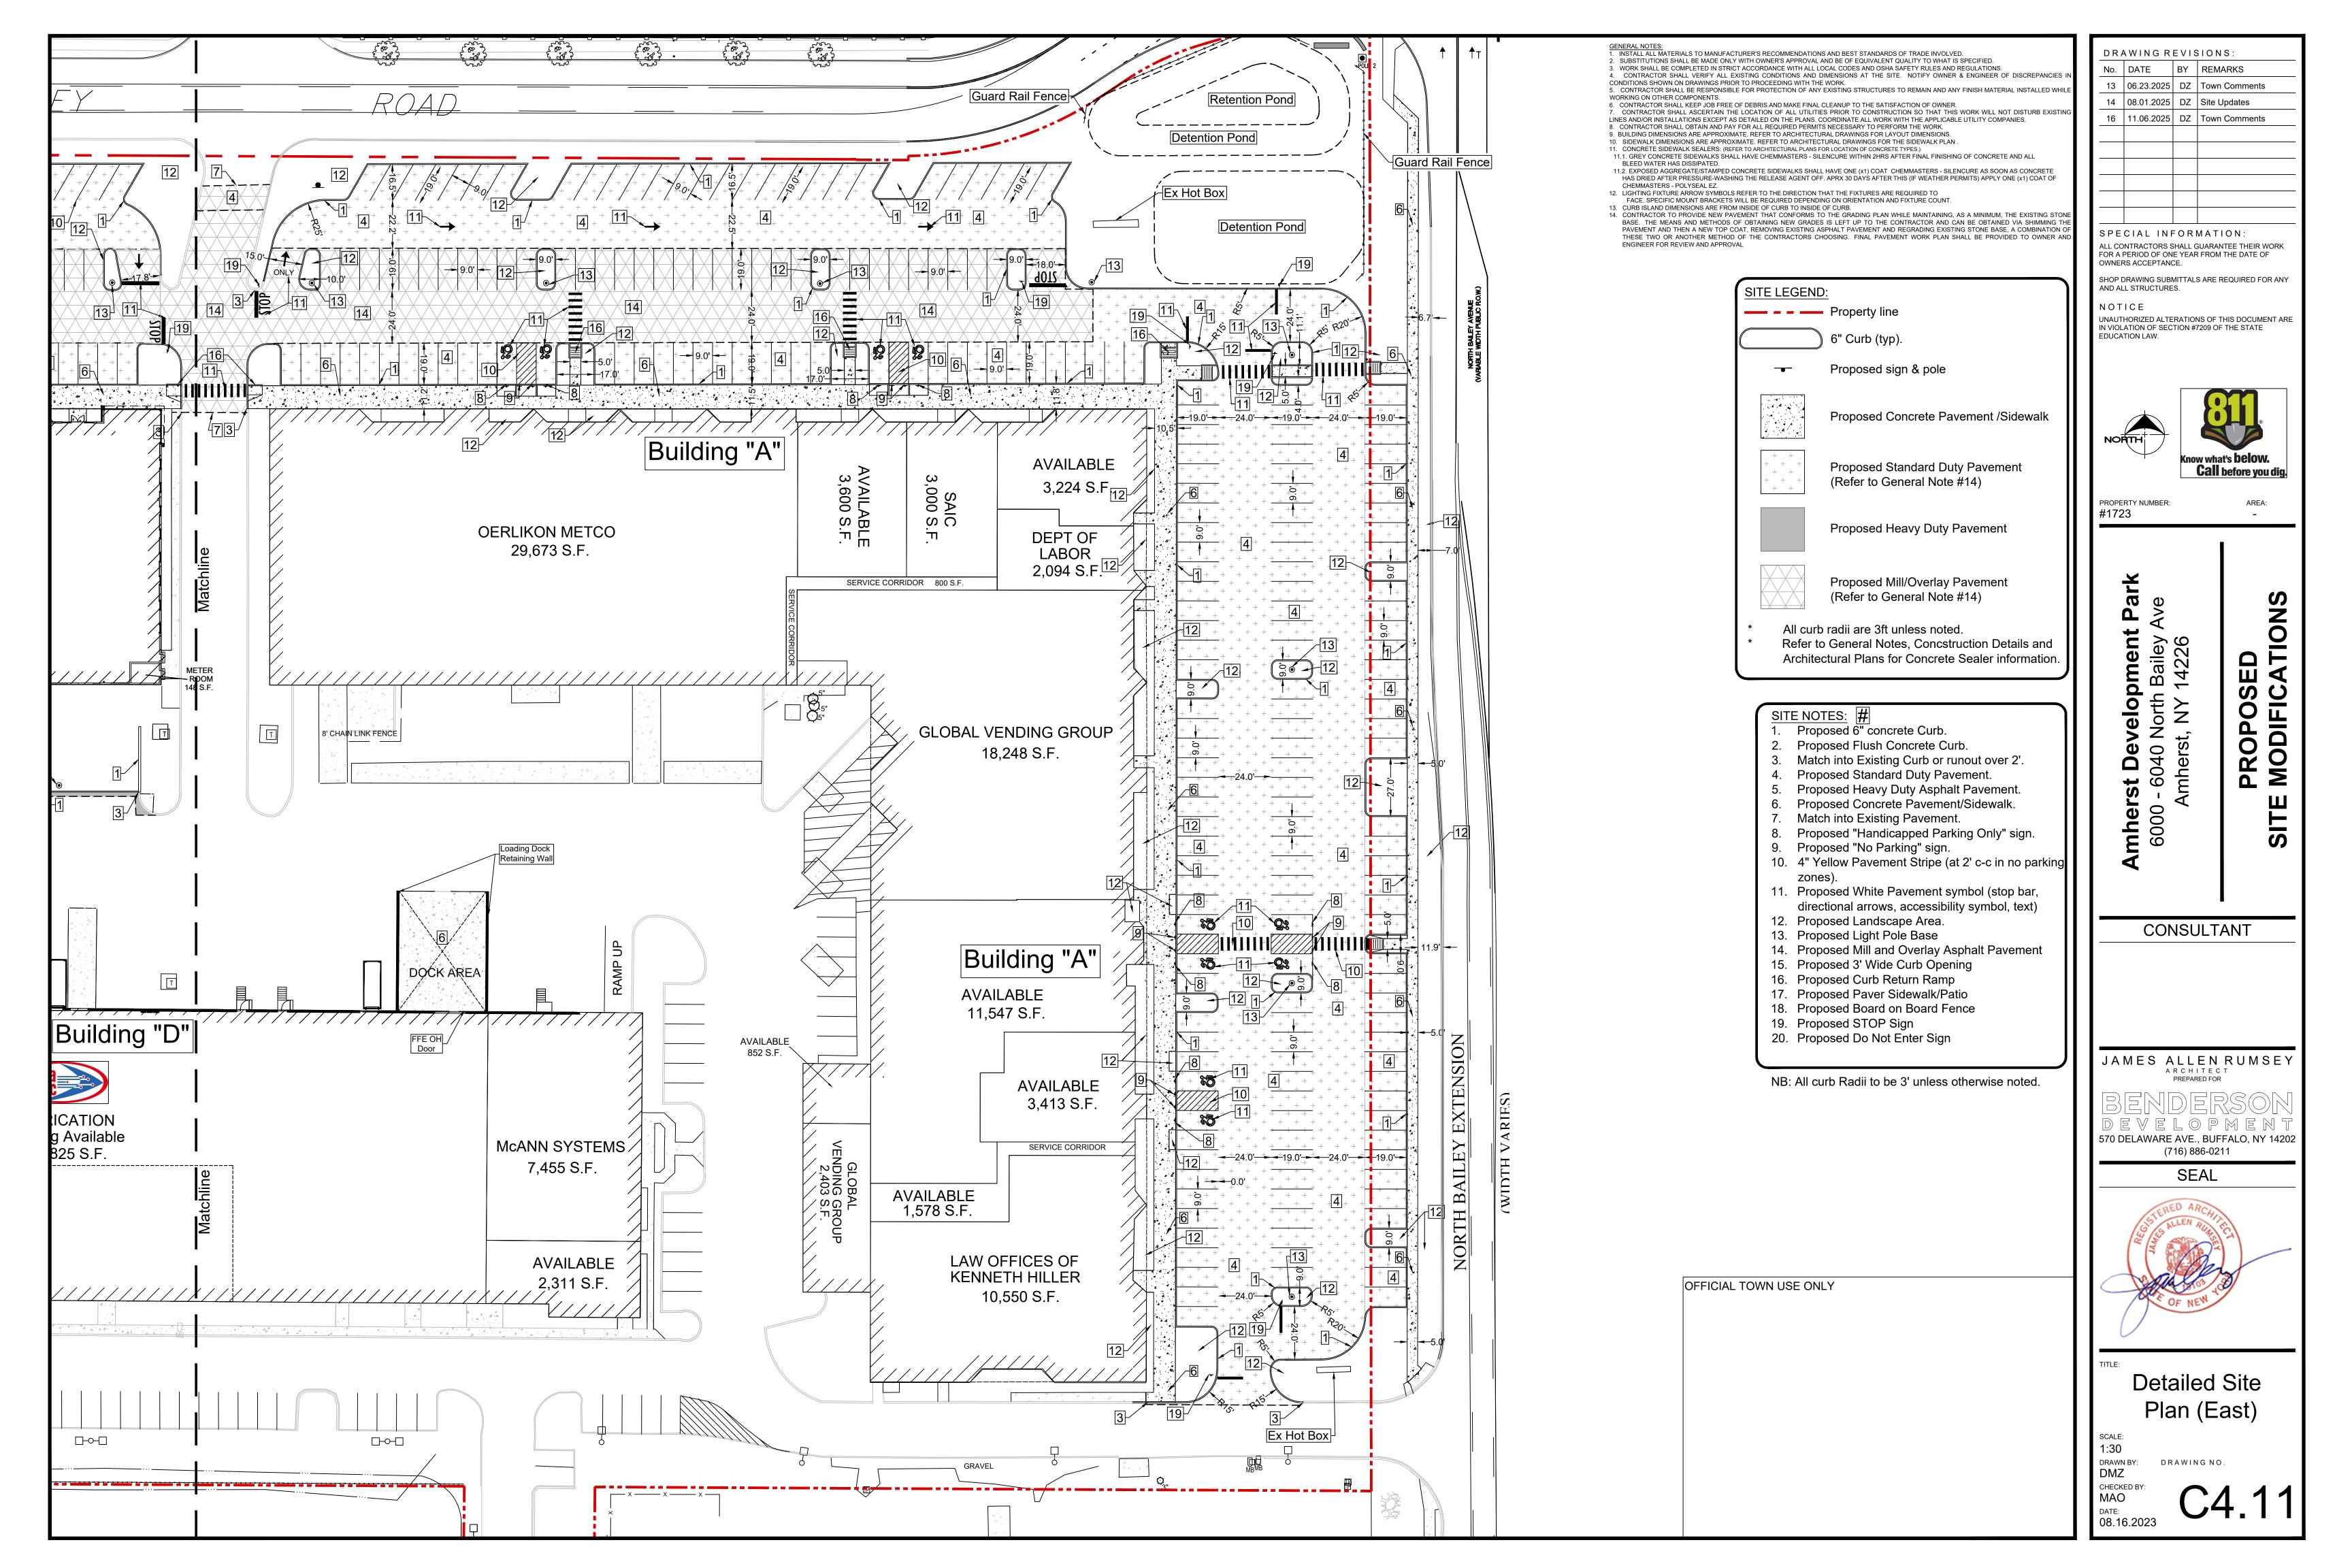


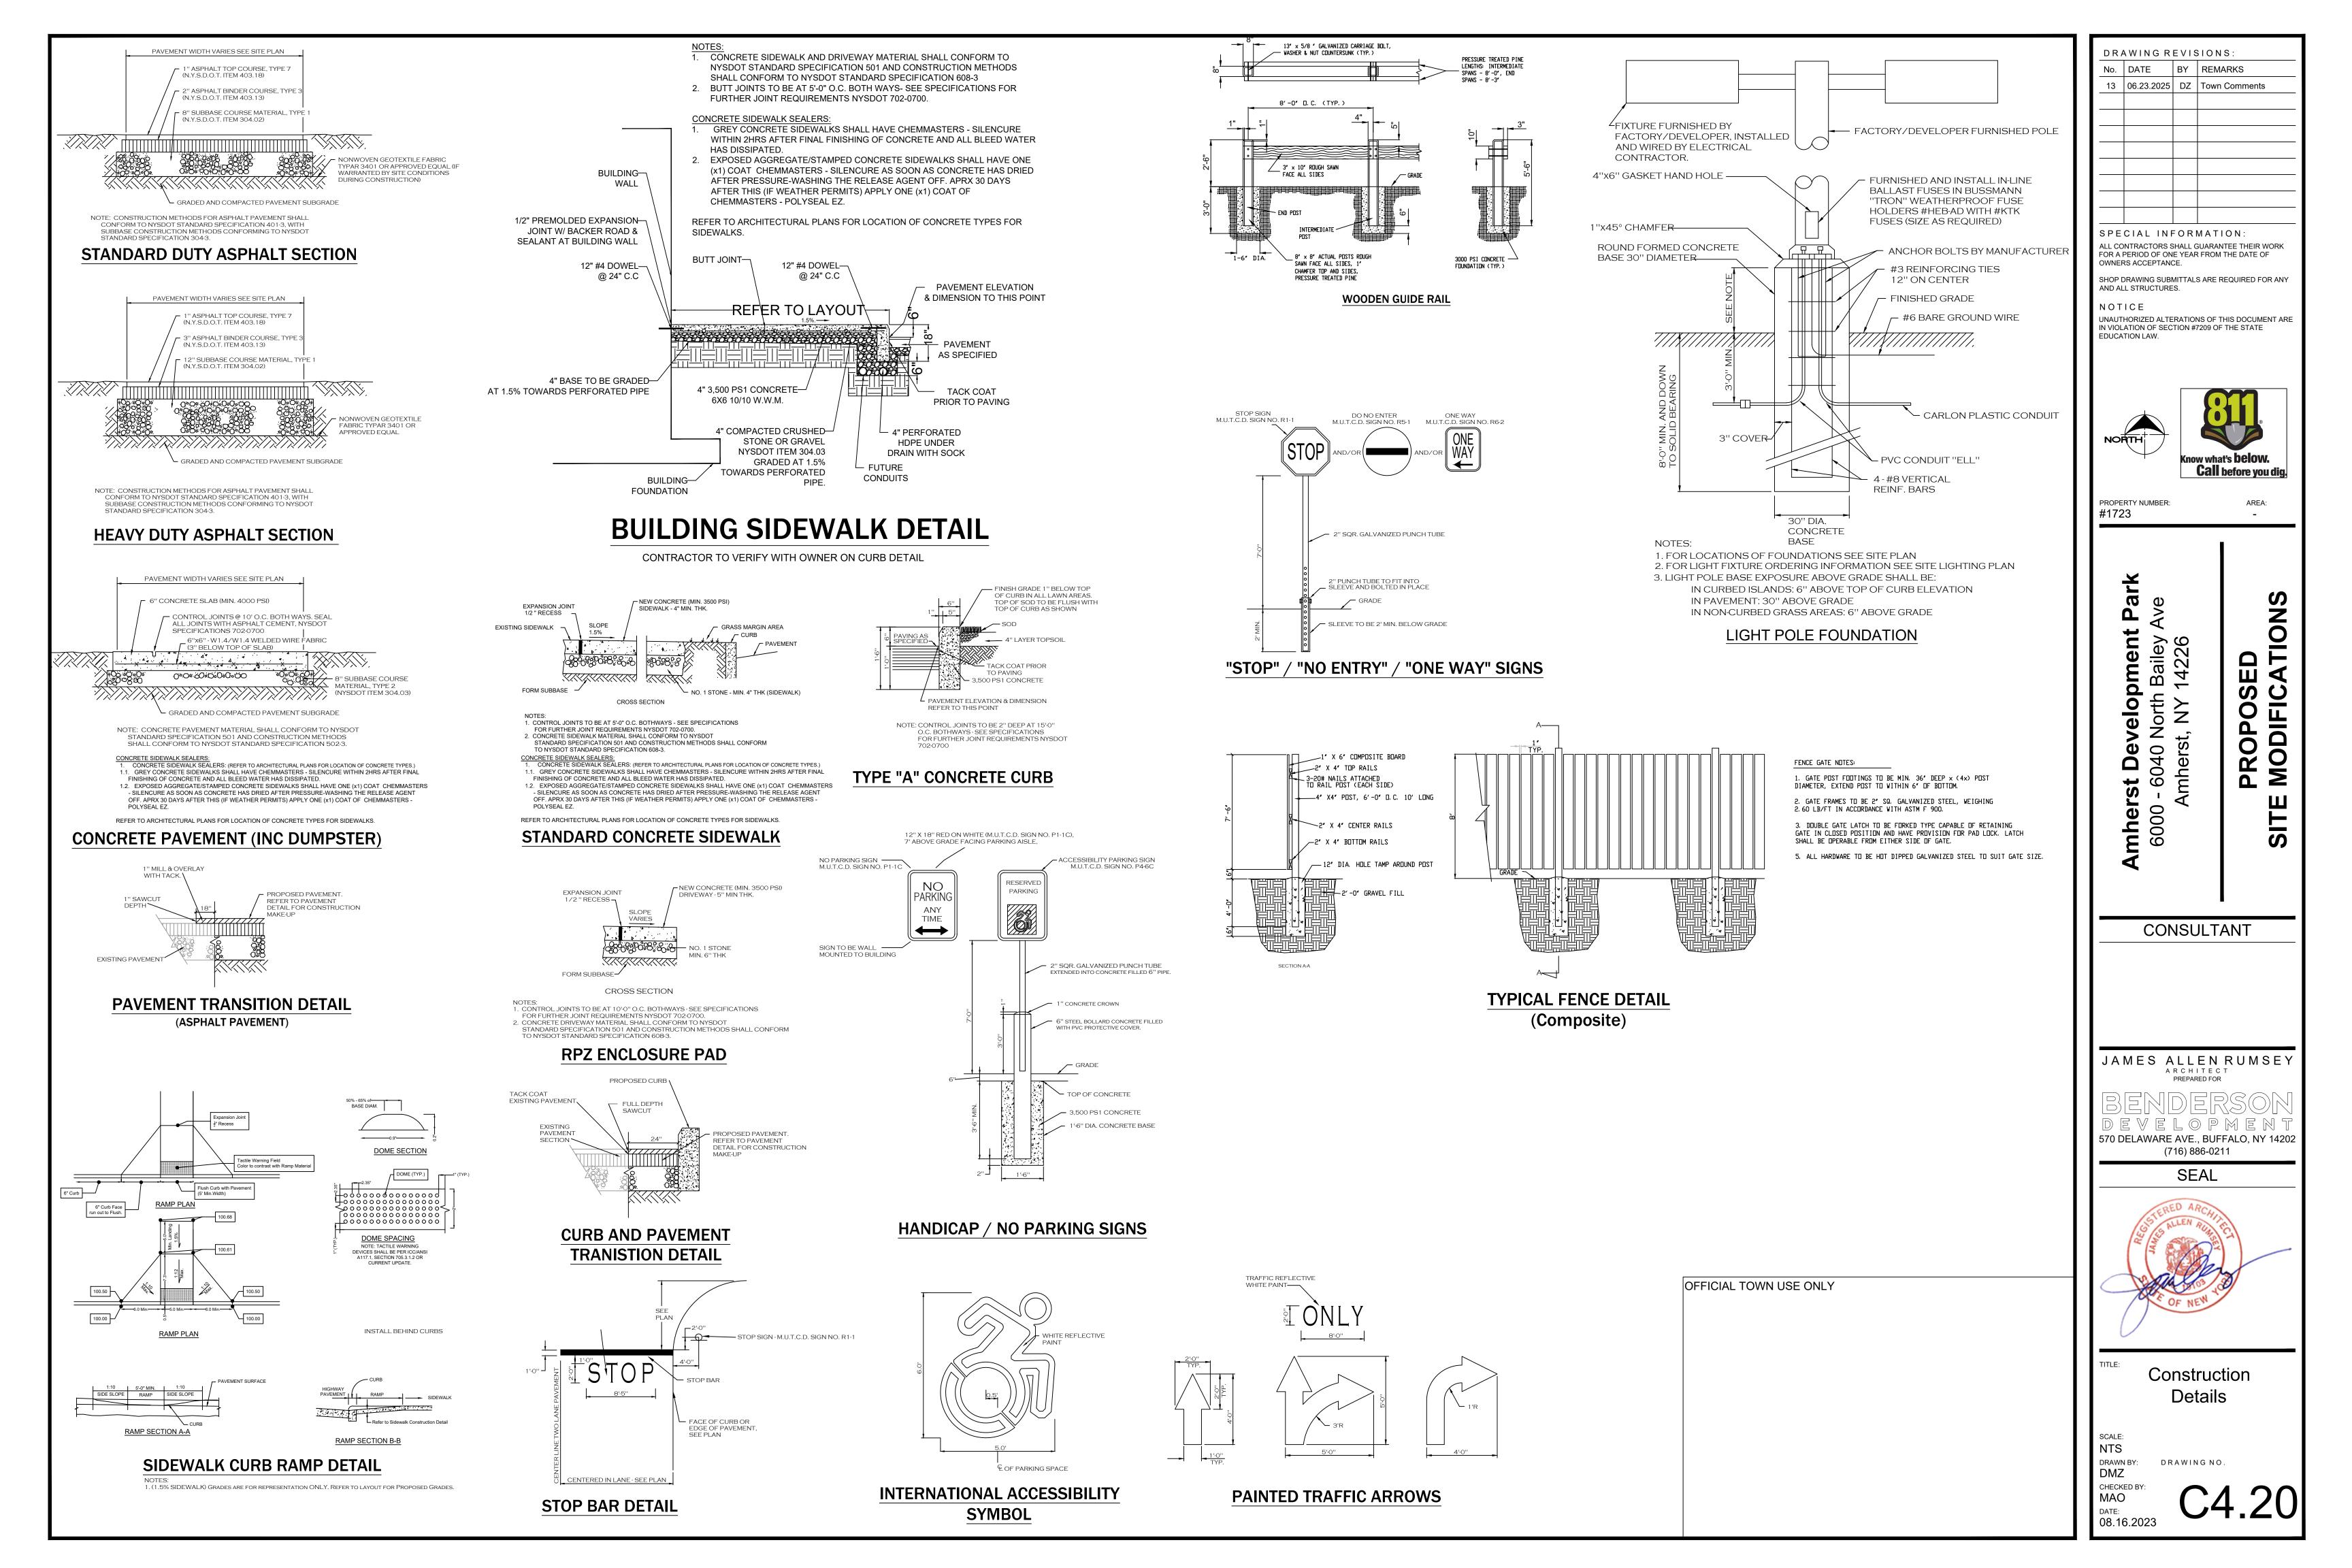

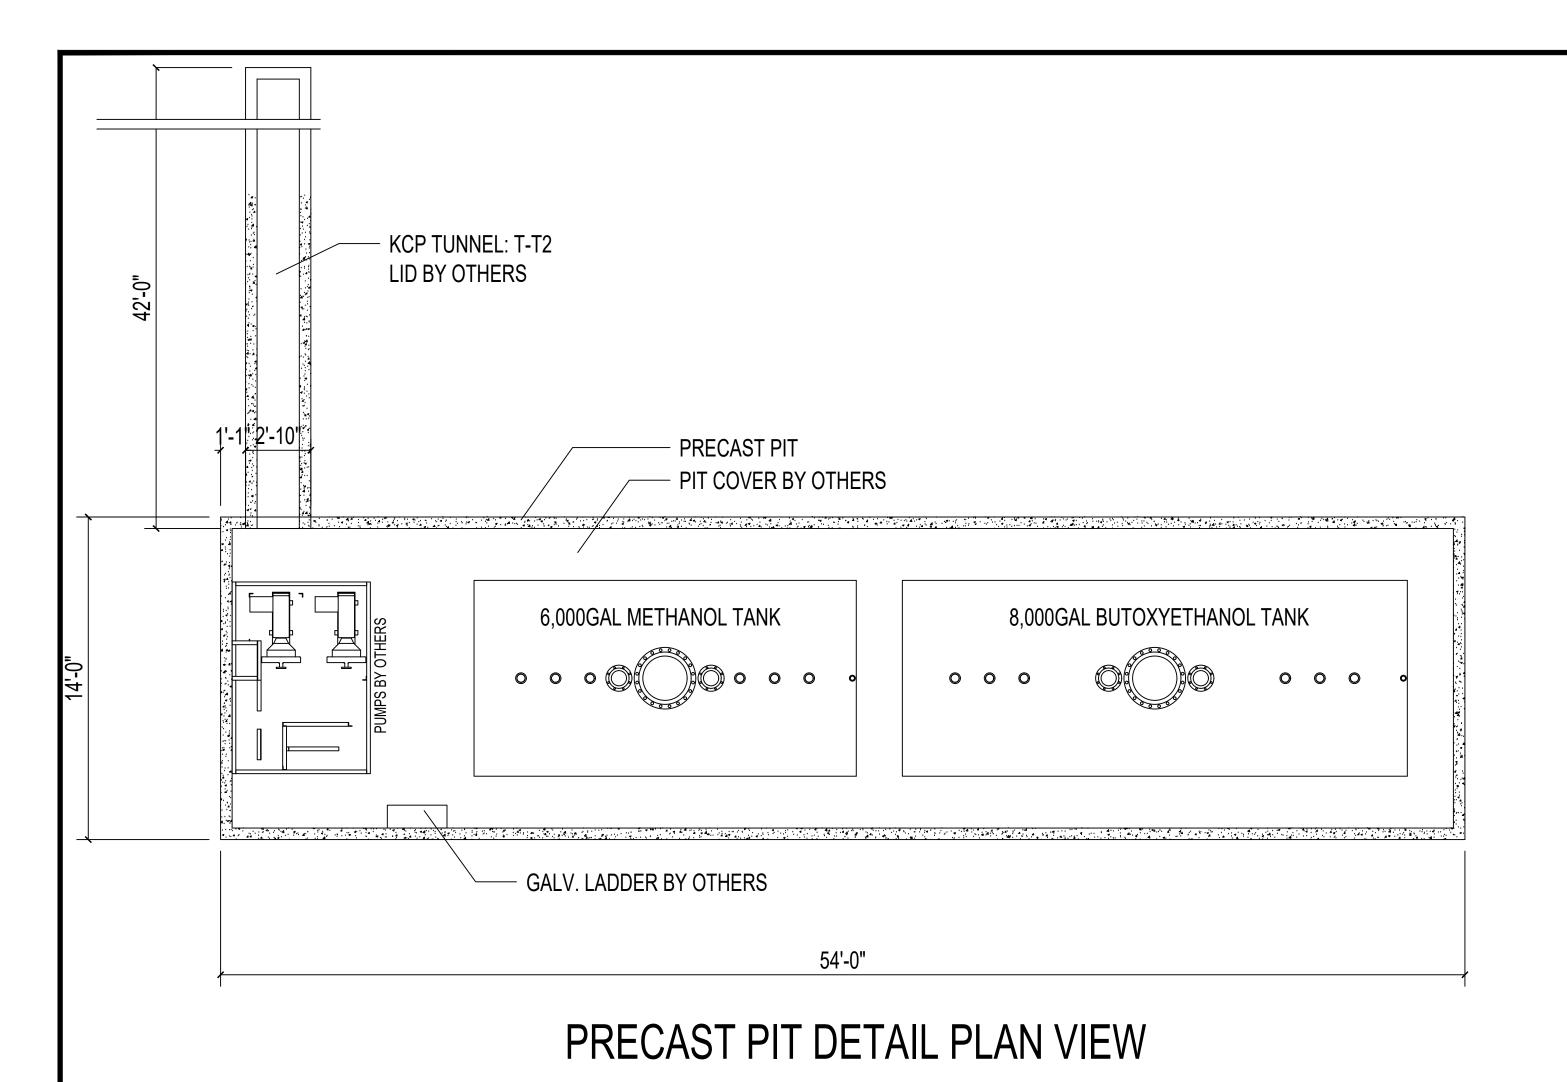


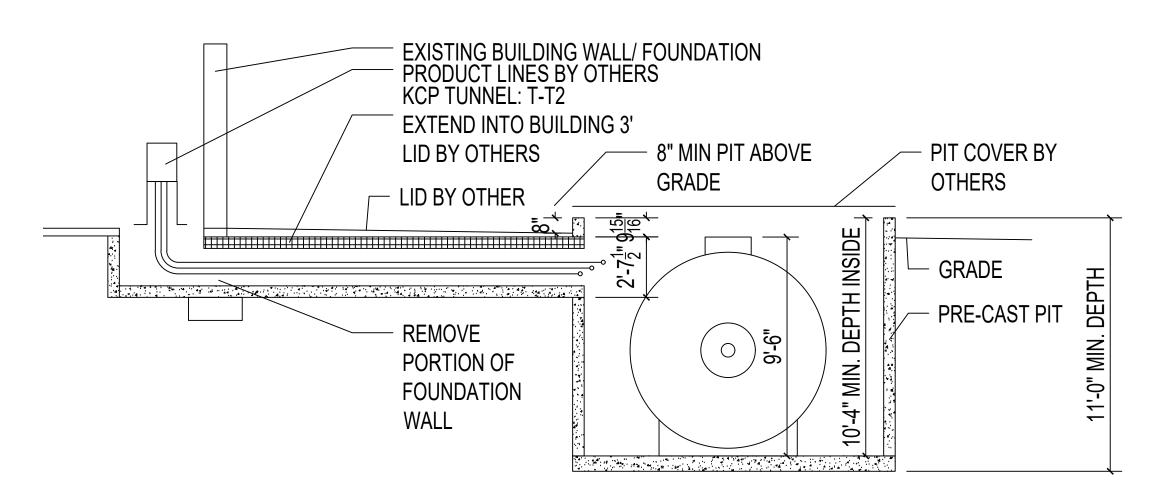



PRECAST PIT SECTION

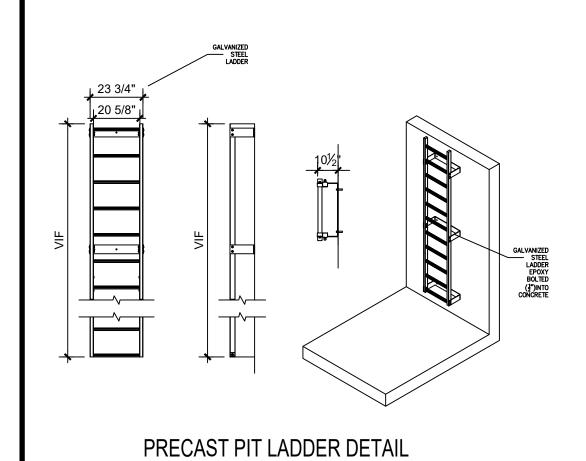



OFFICIAL TOWN USE ONLY

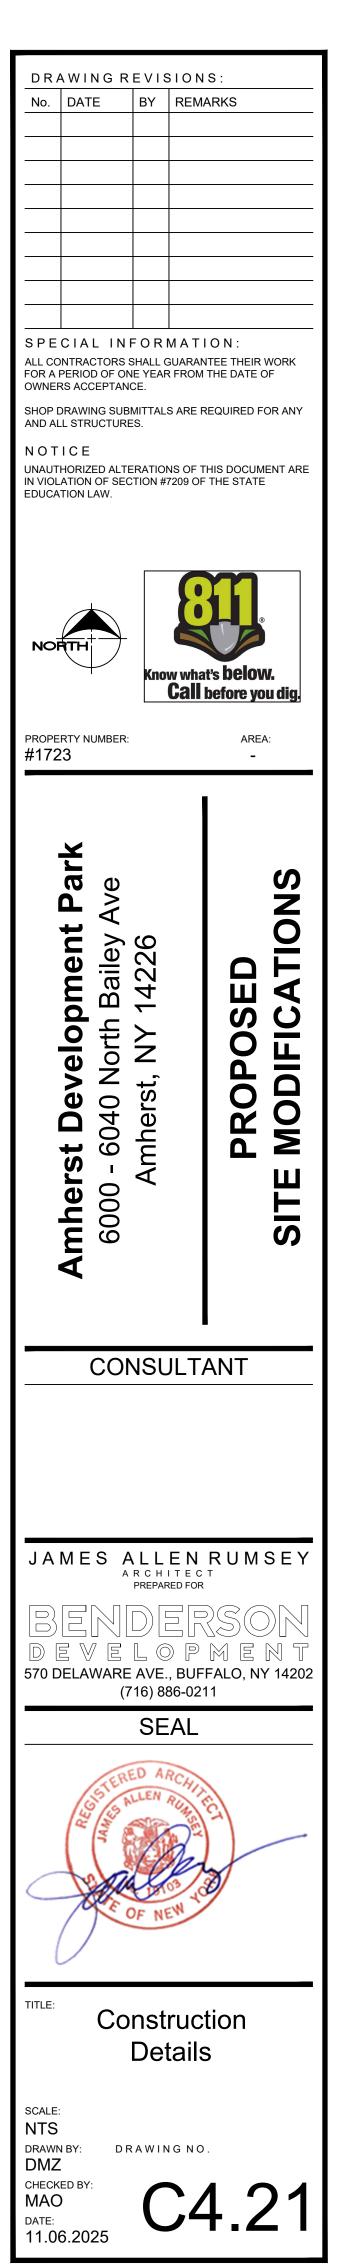


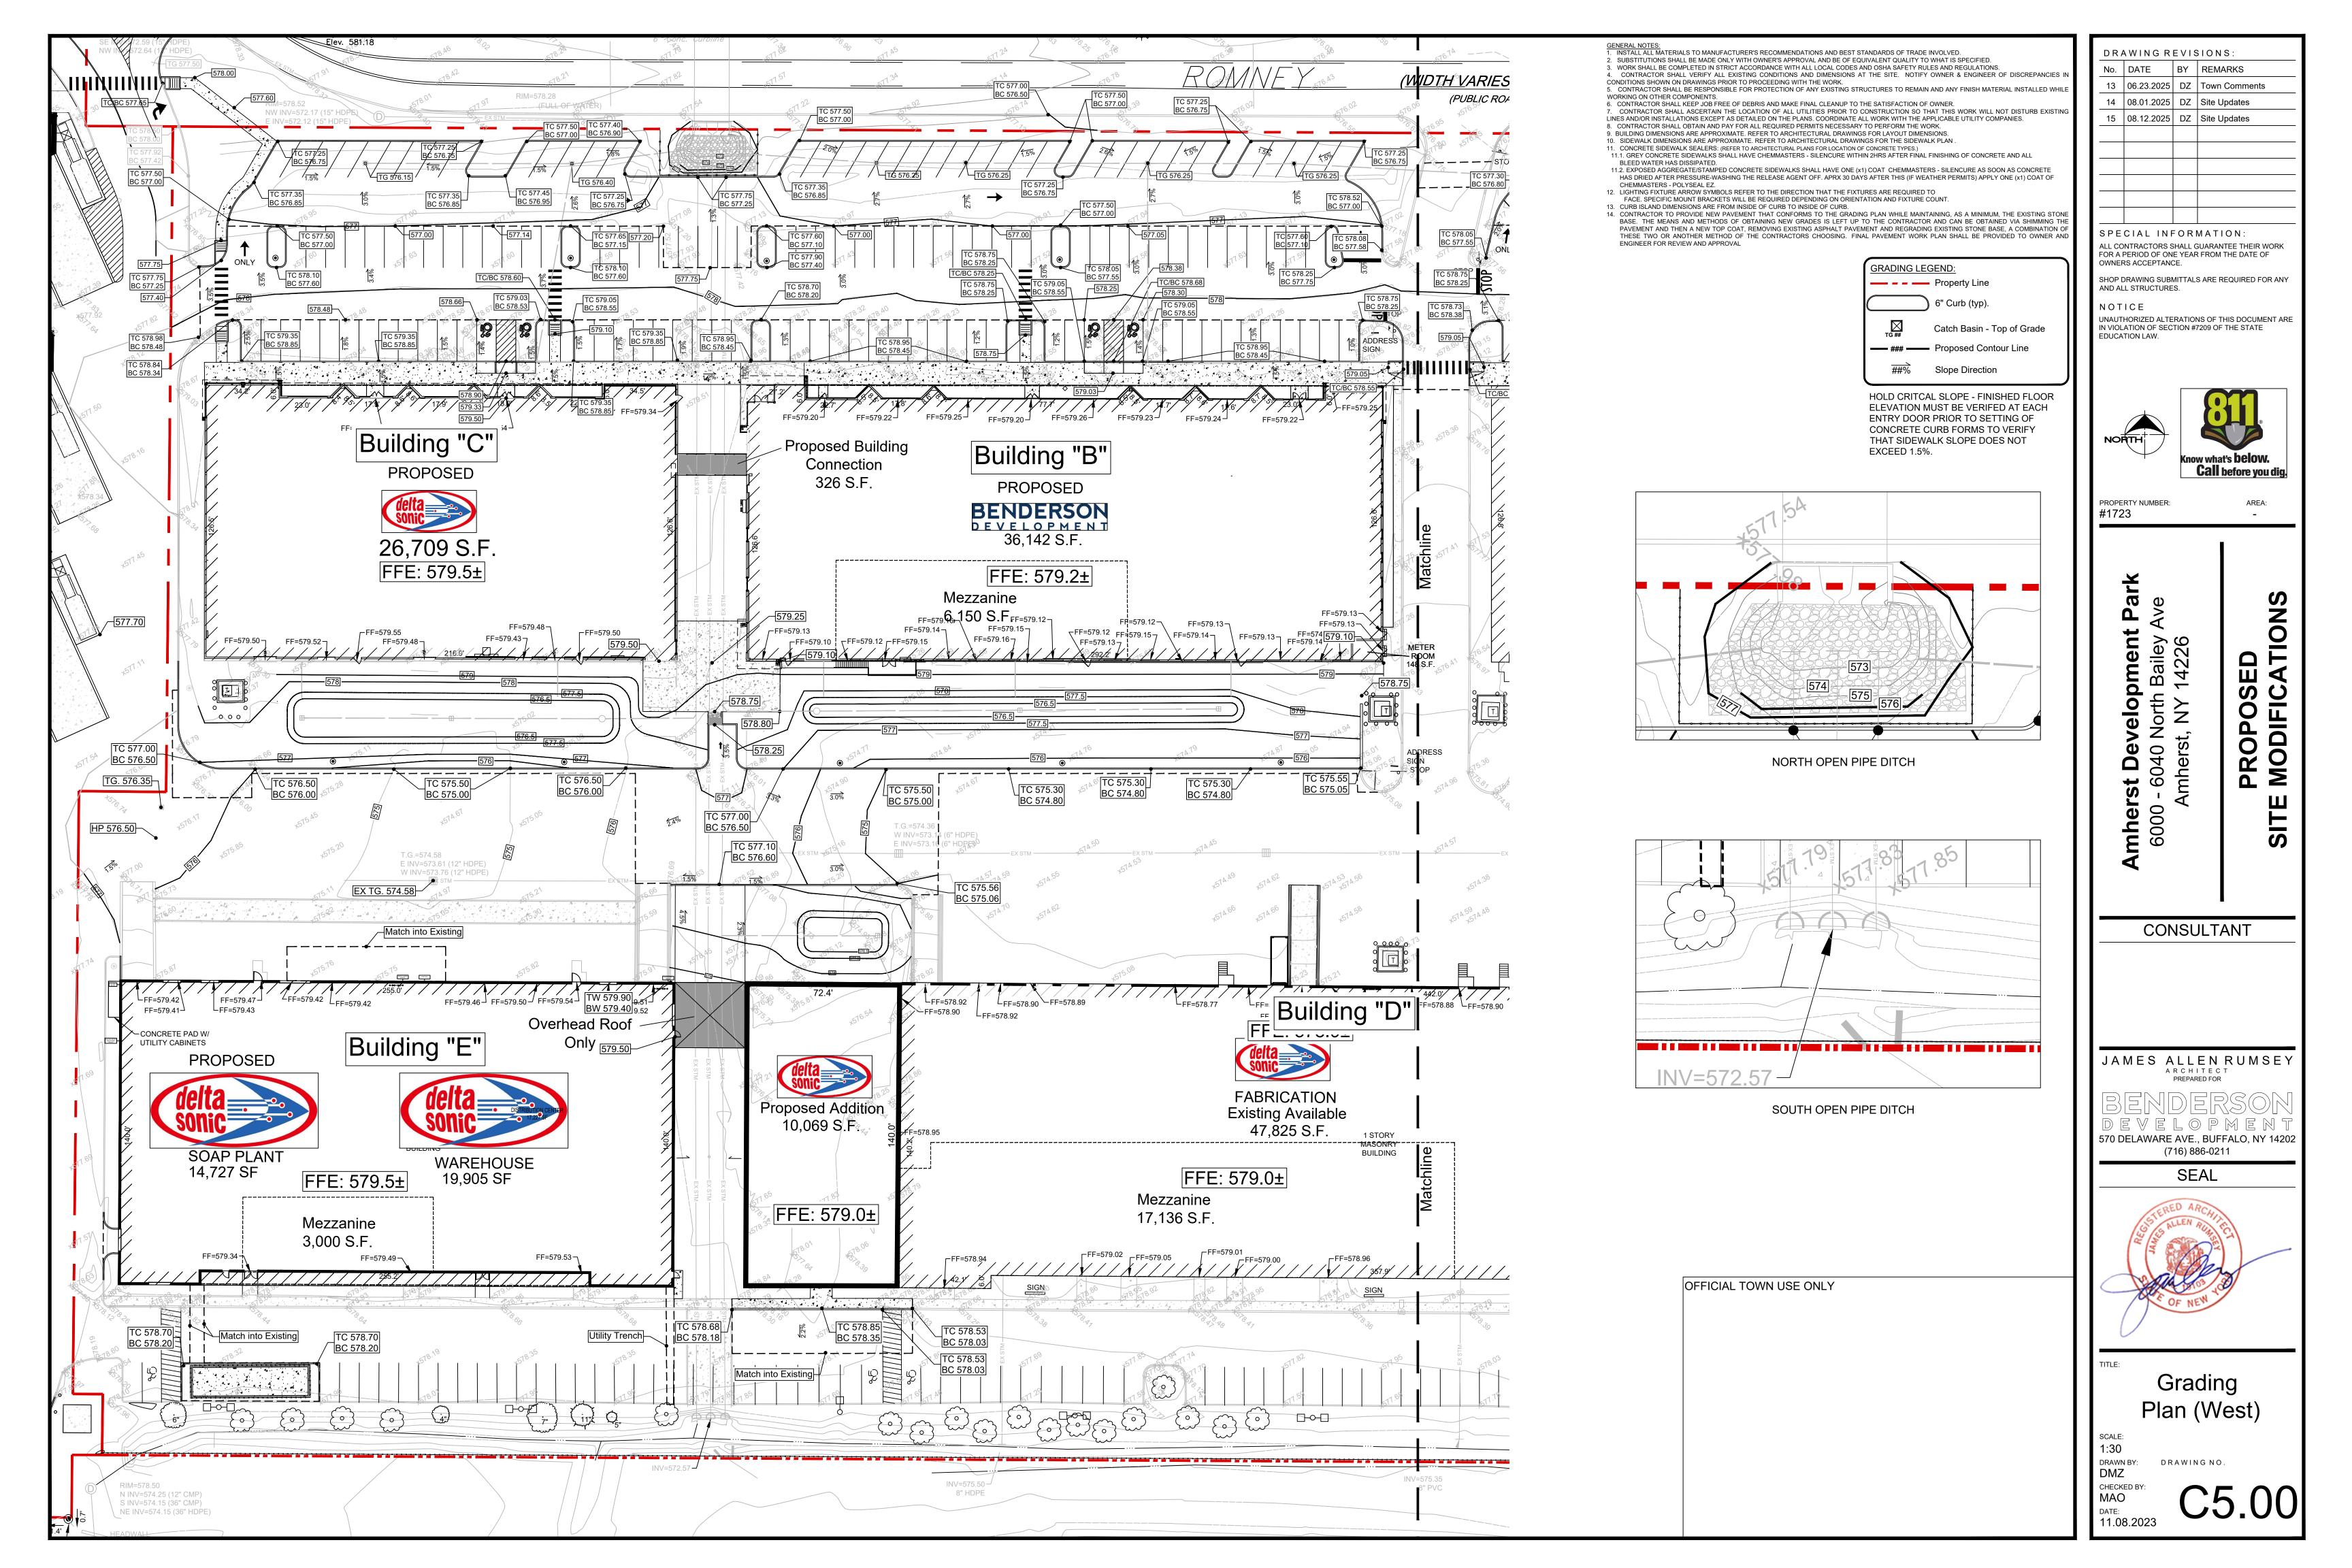

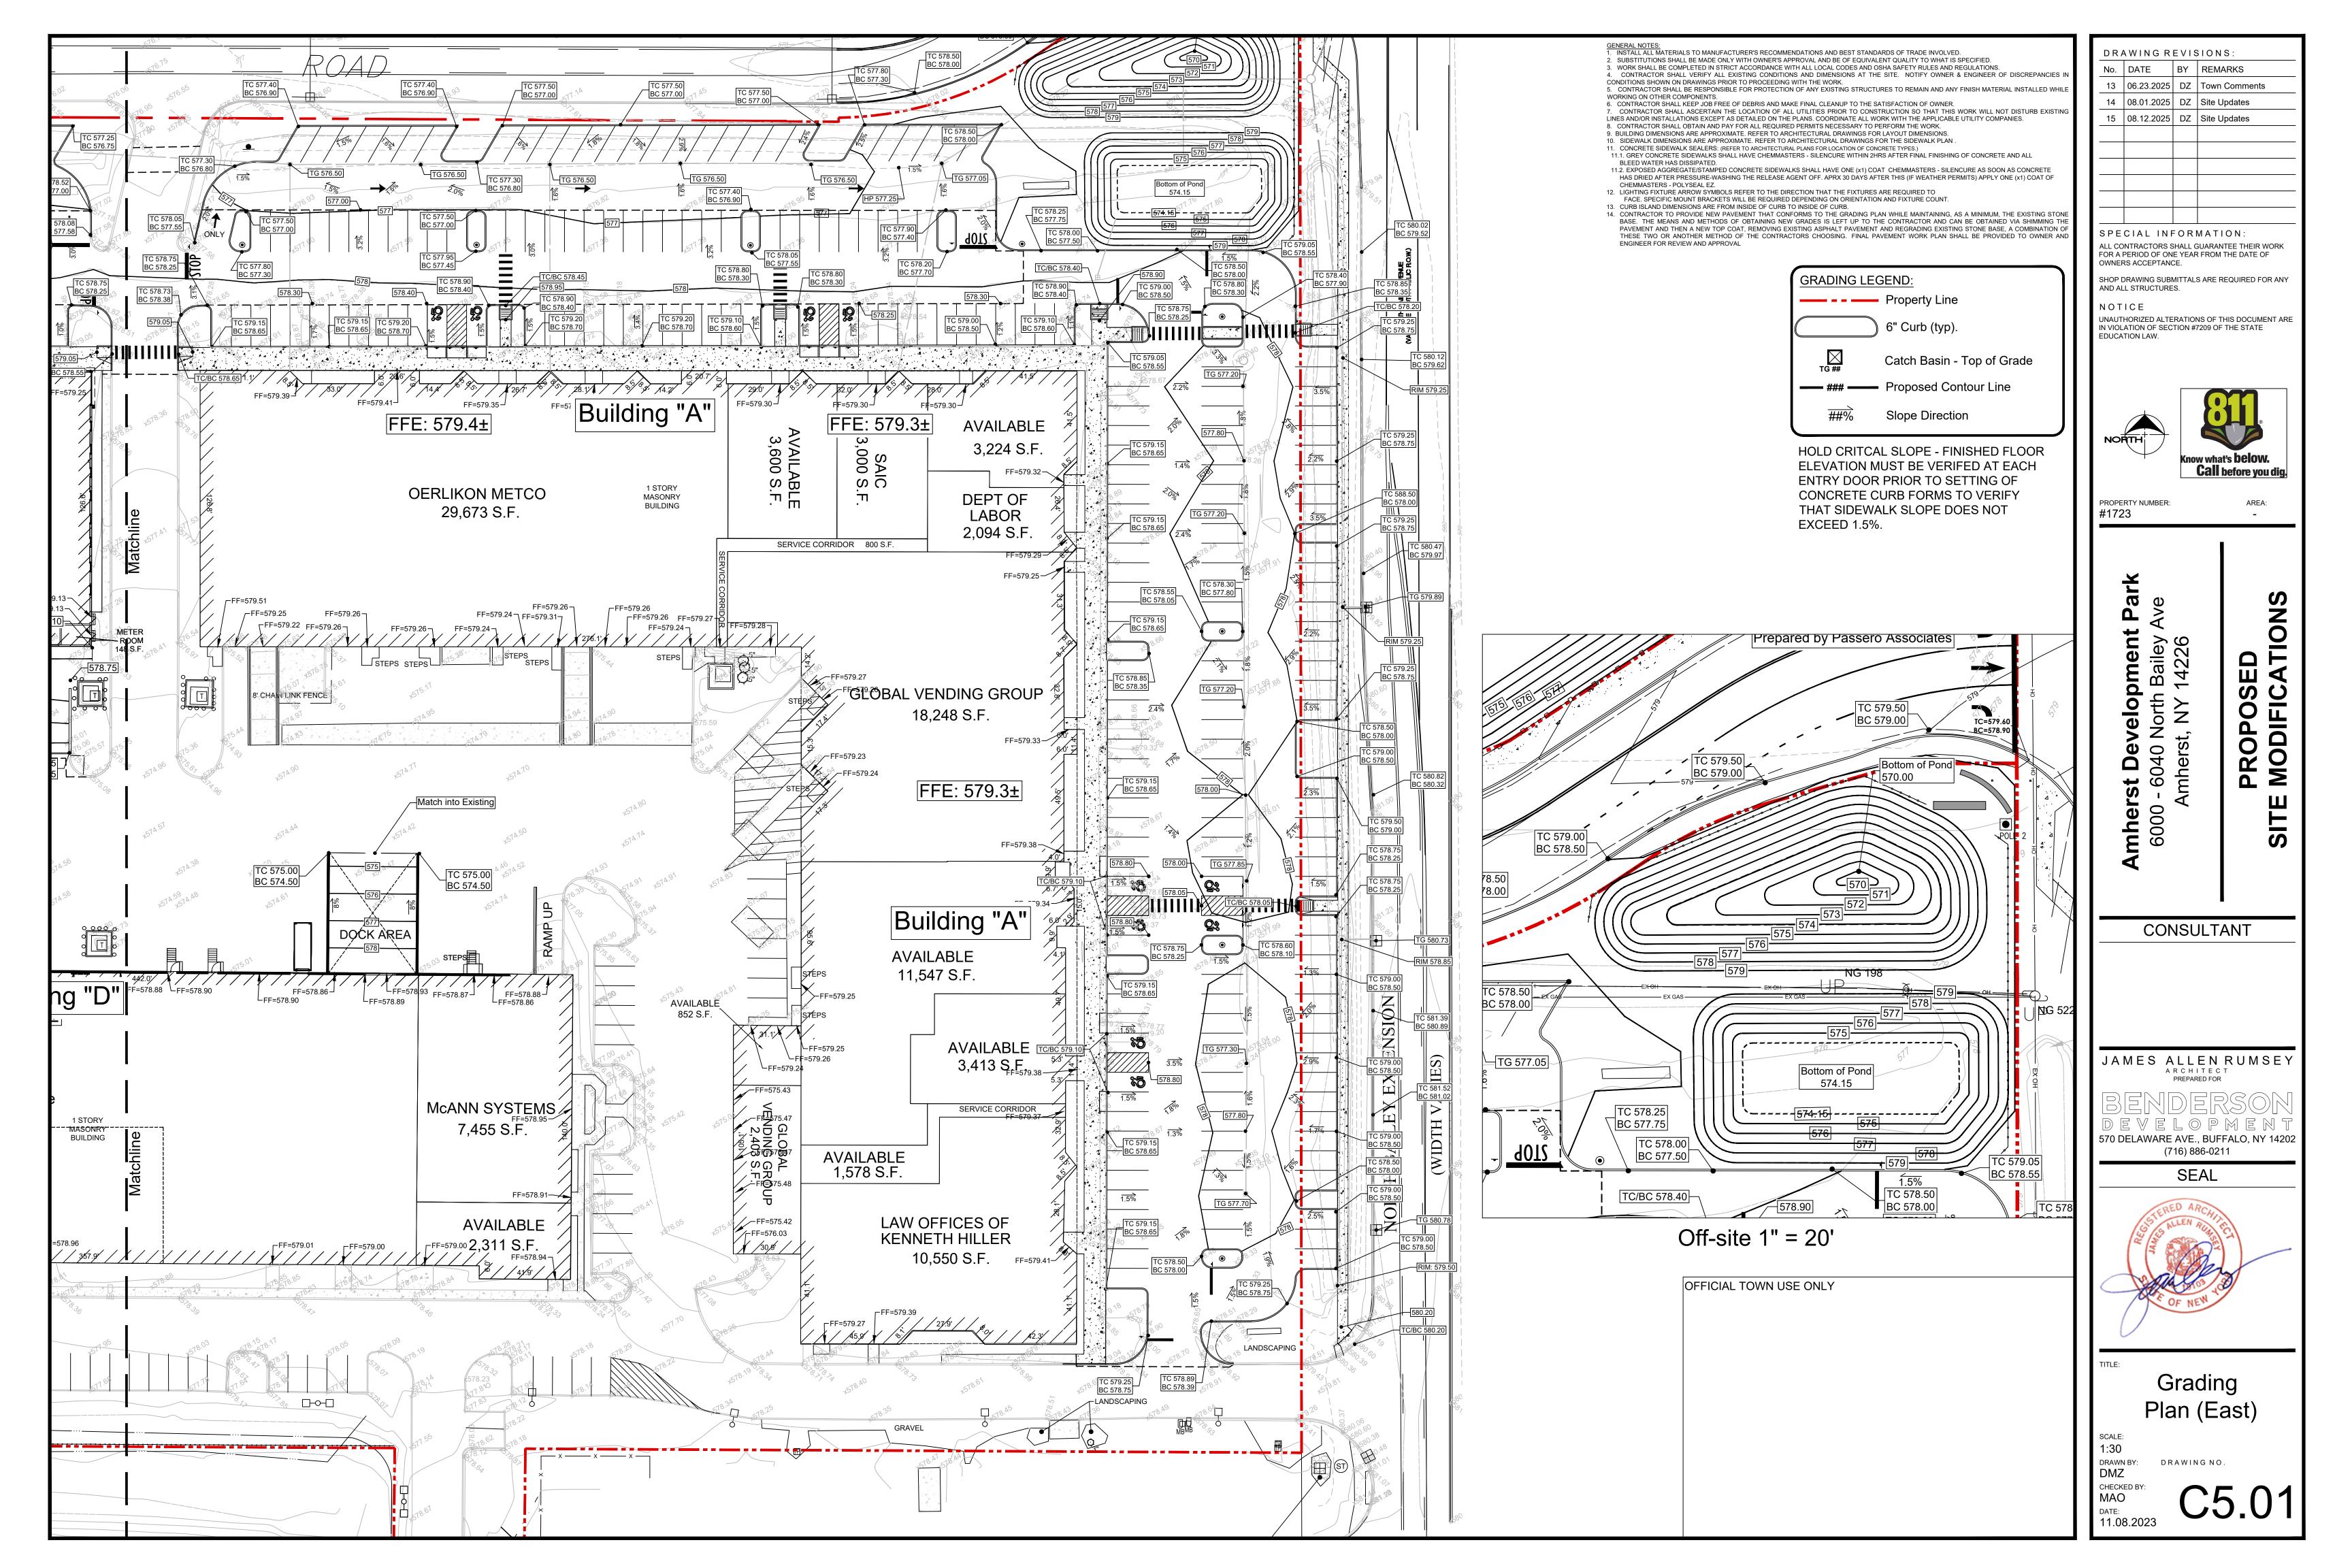

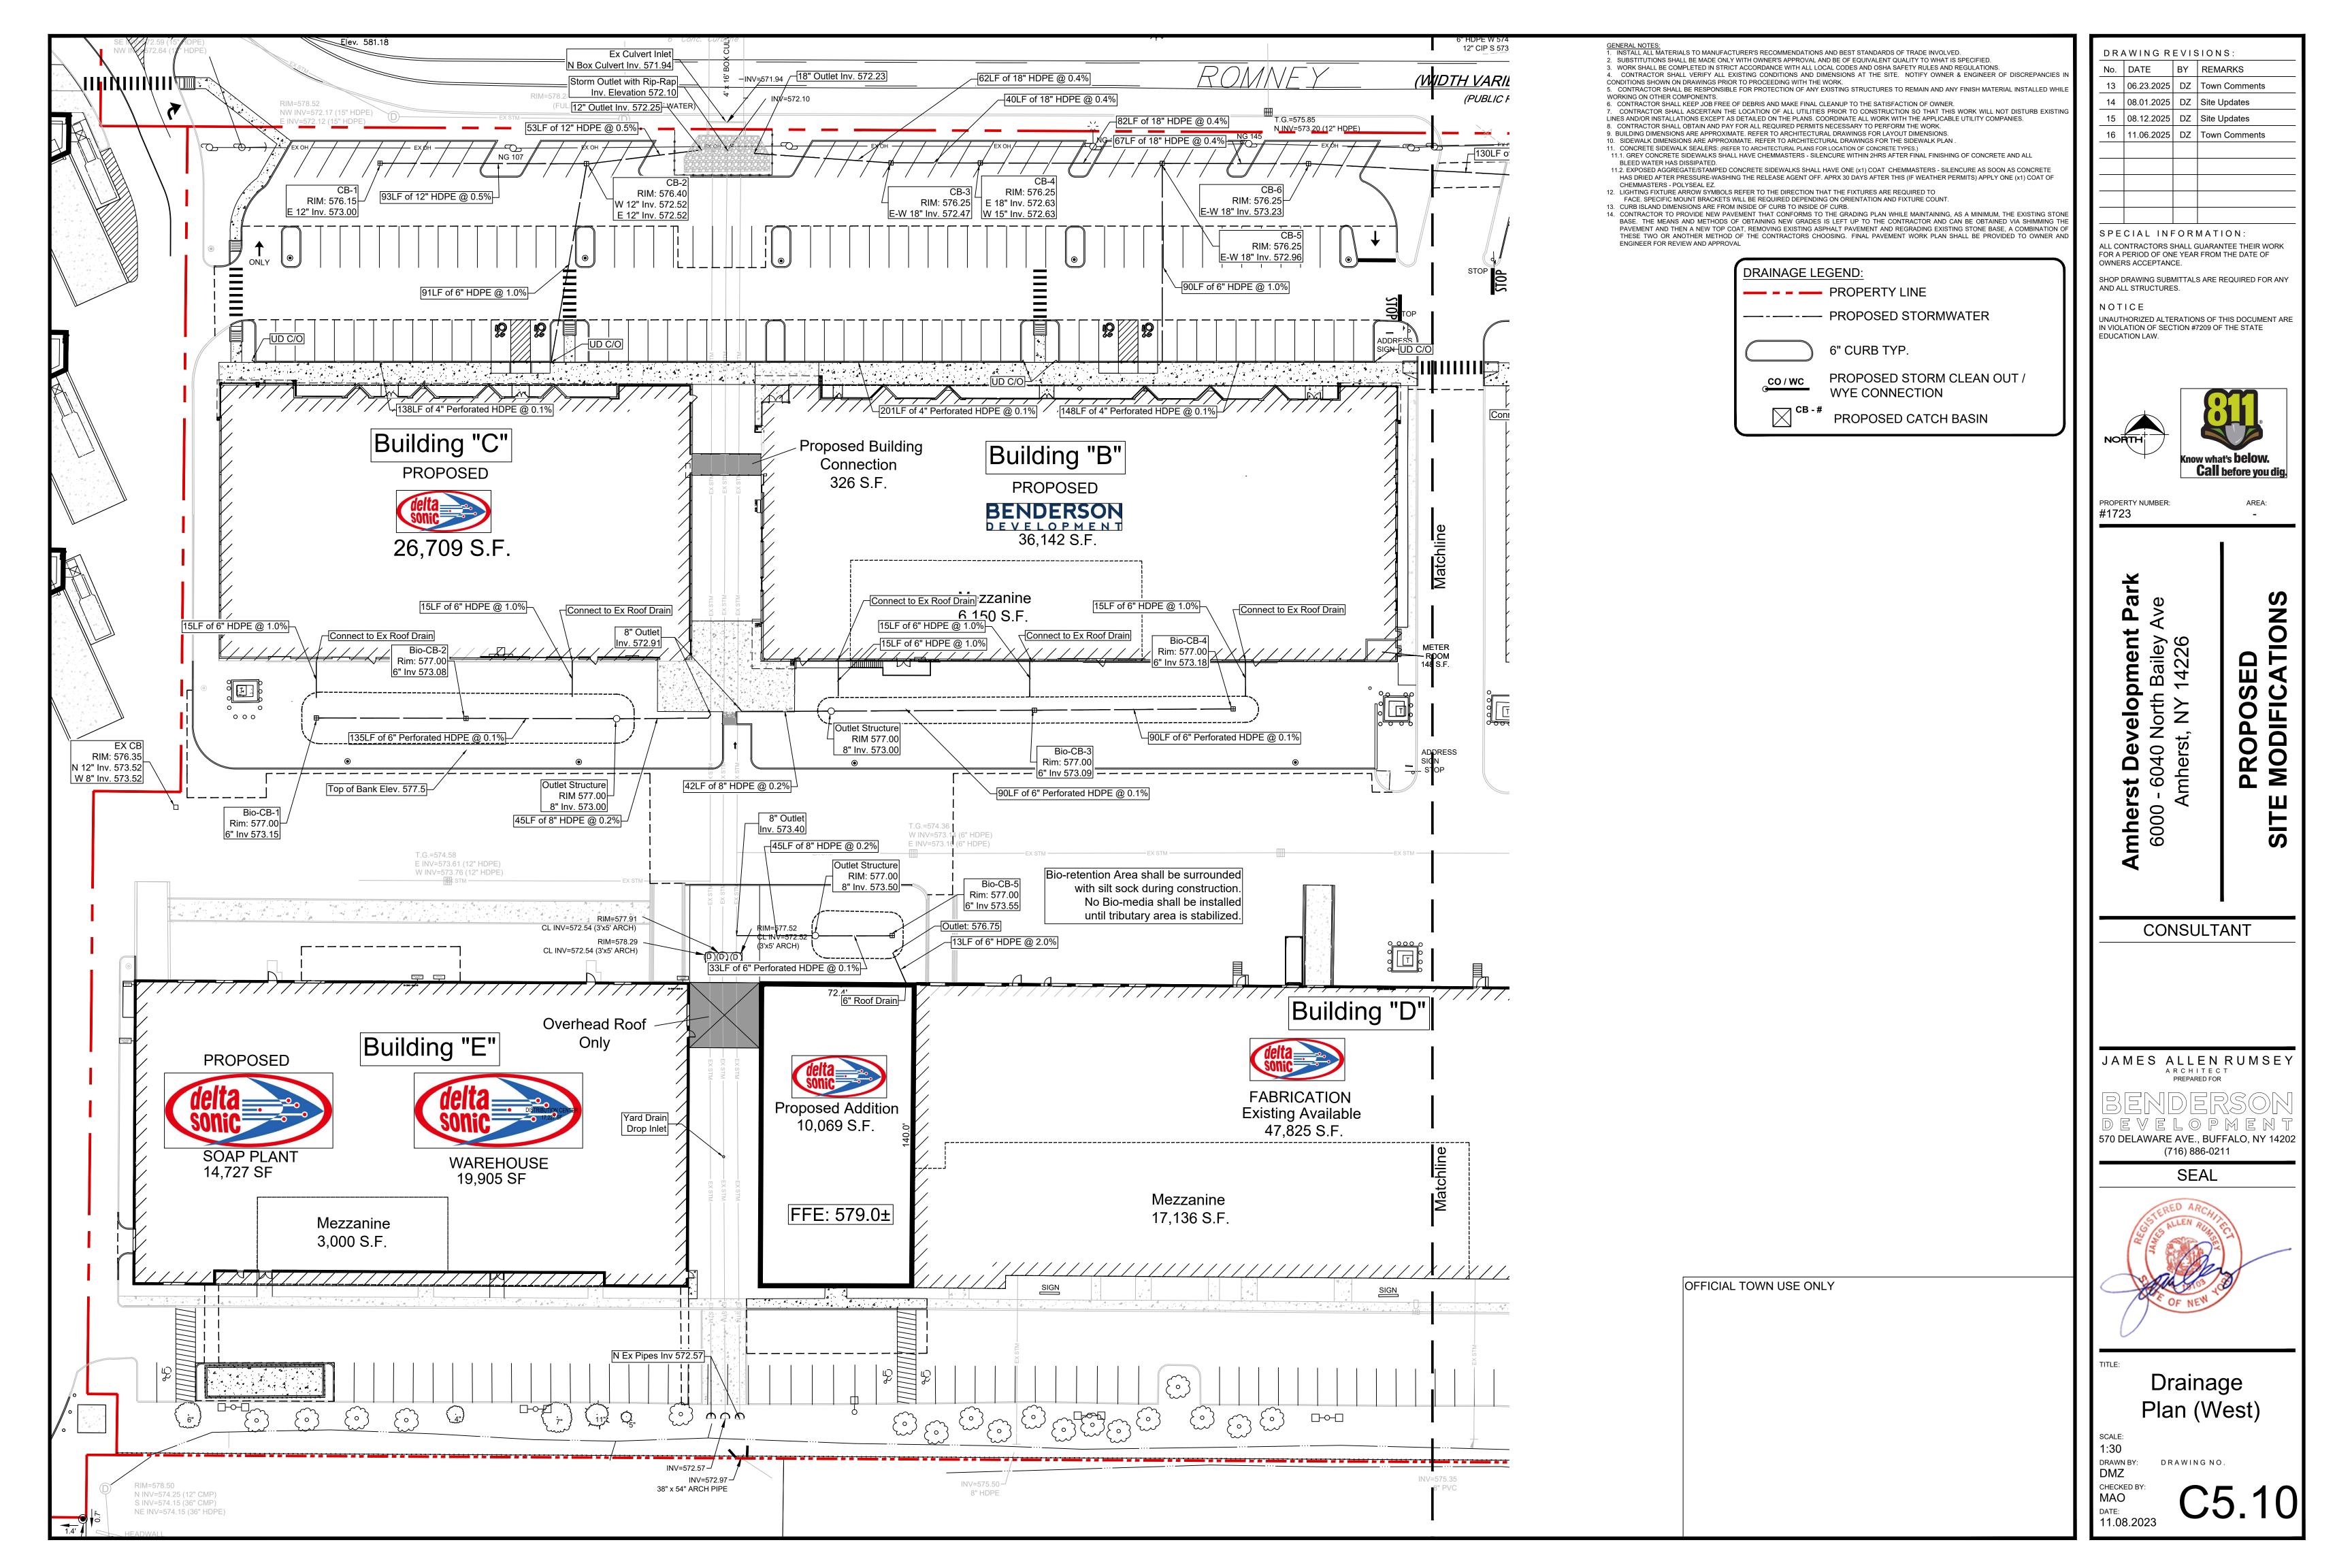

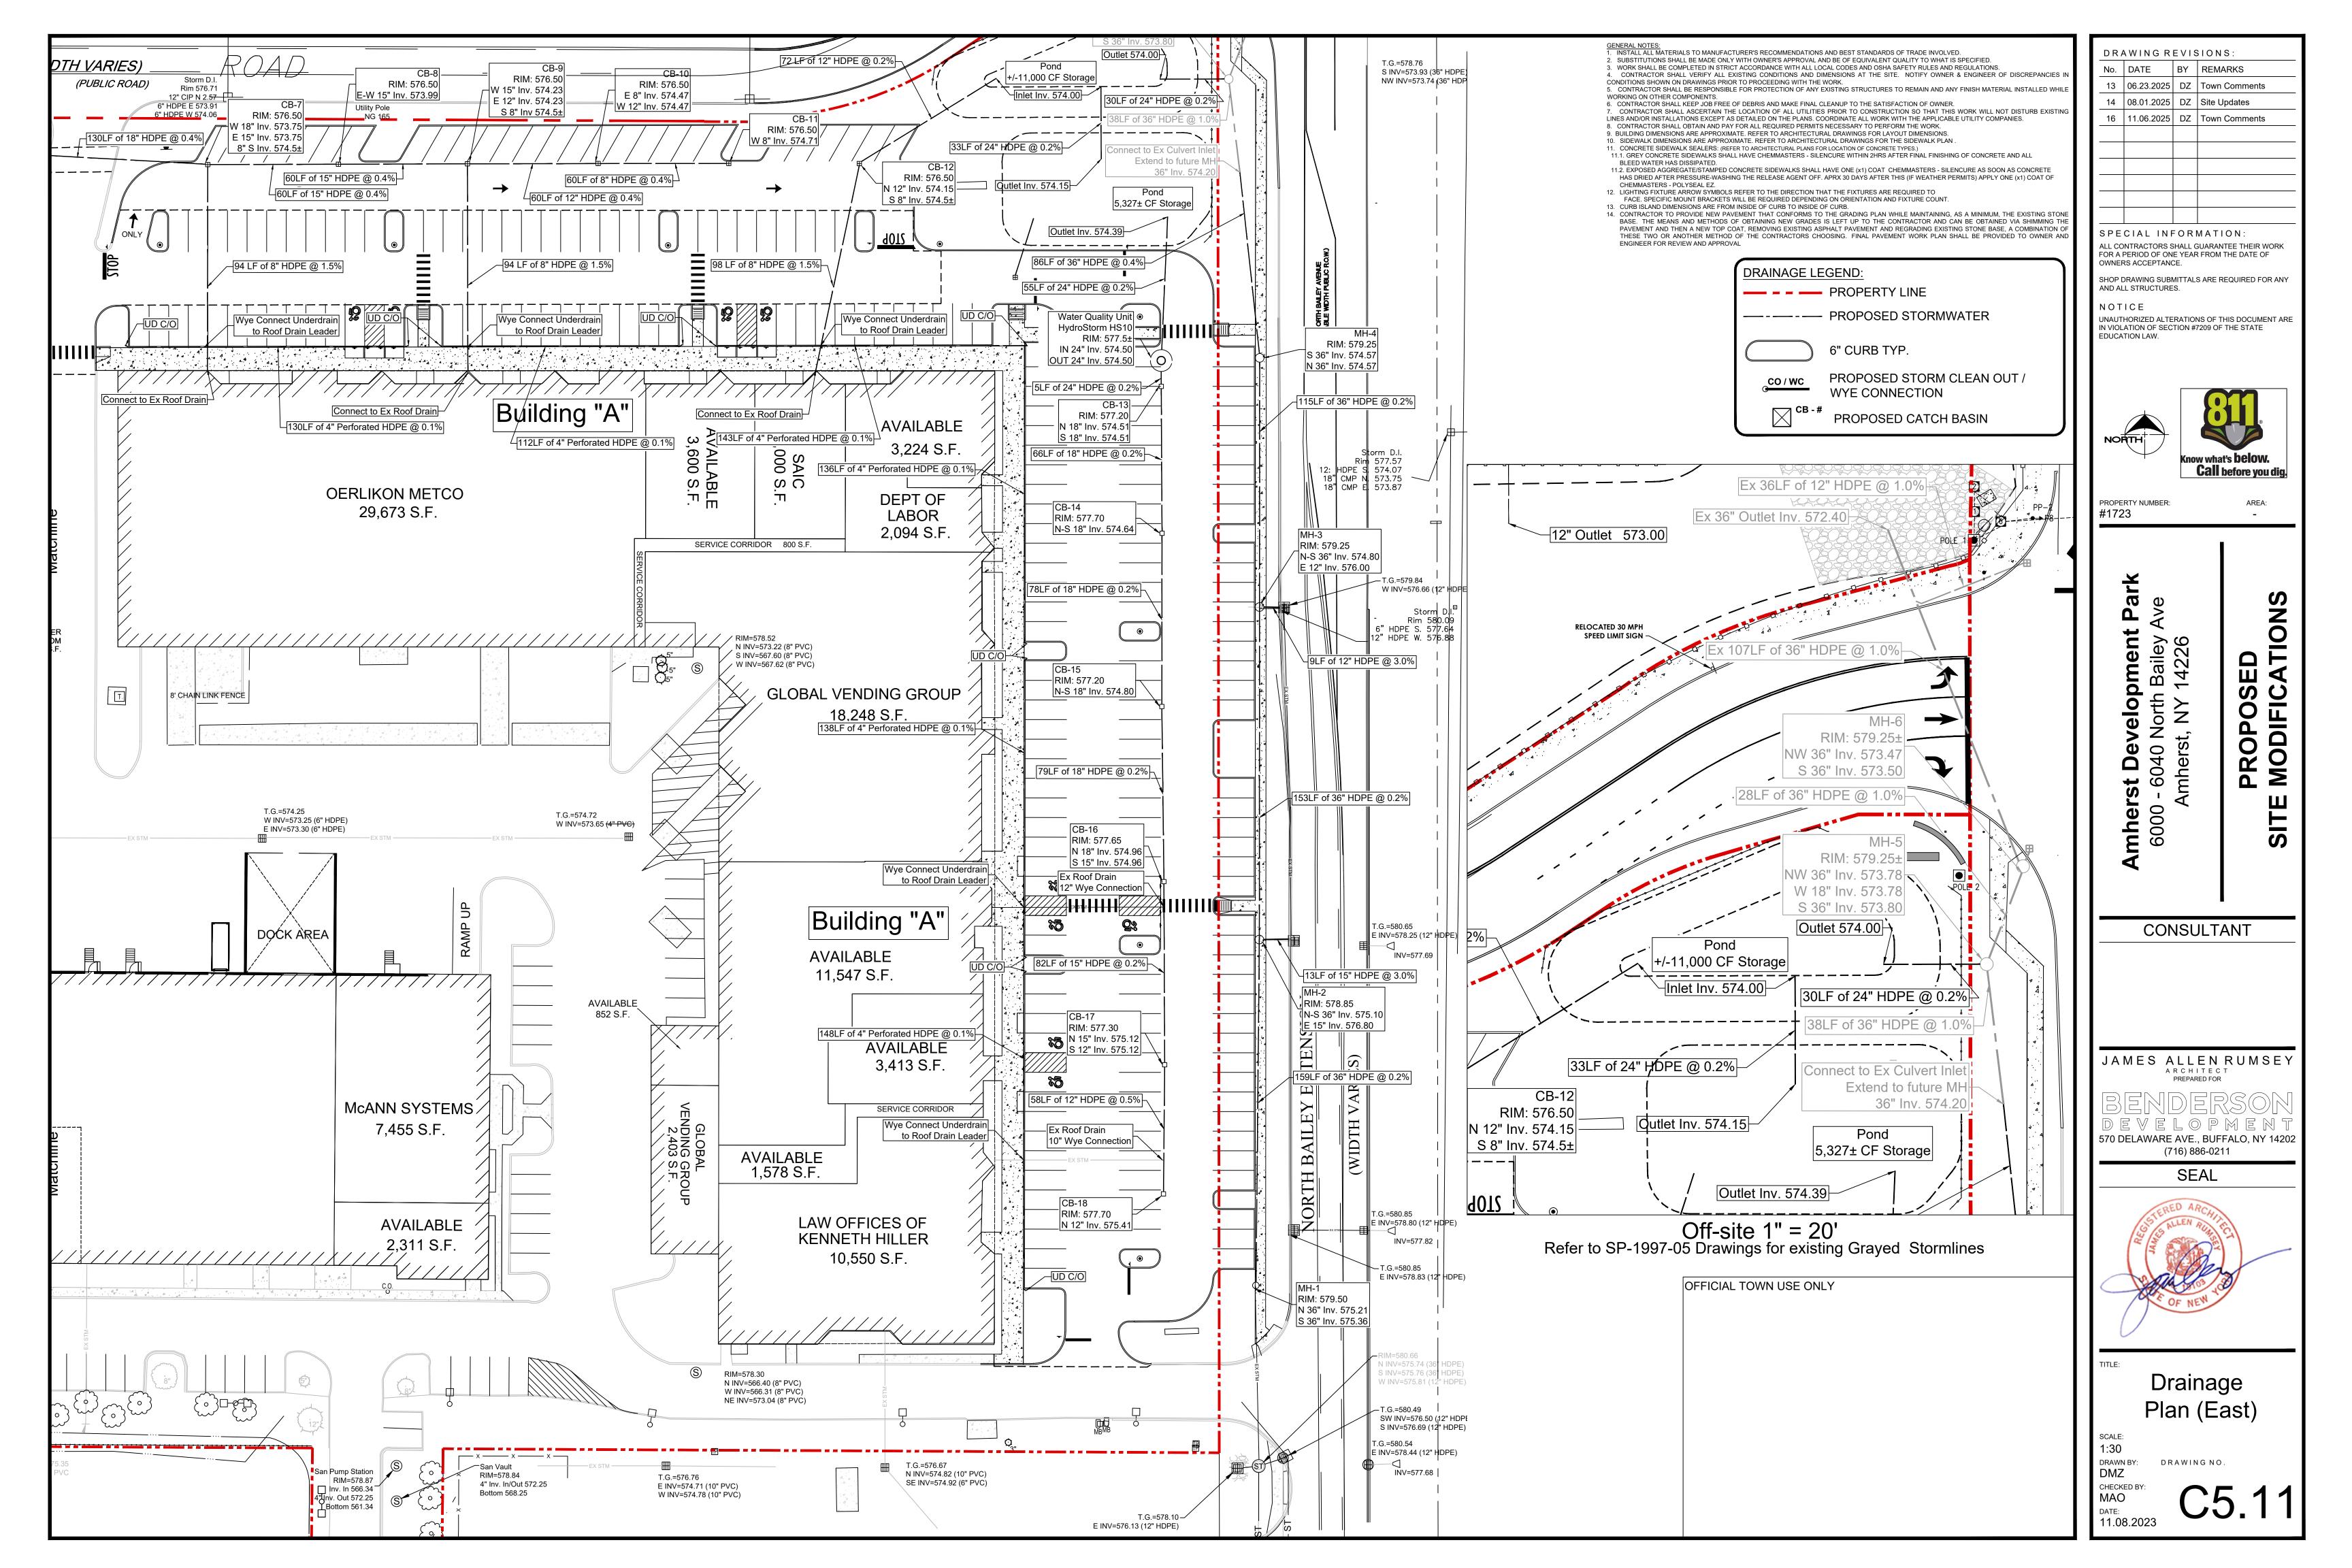

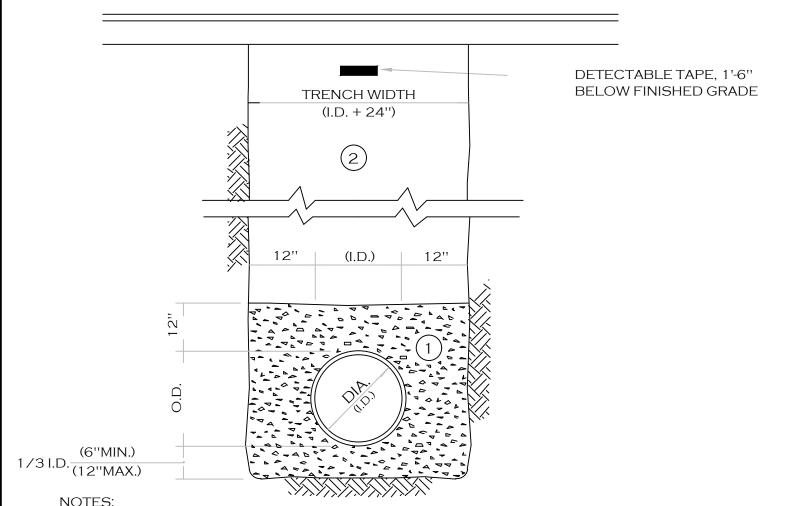

- NOTES:
 - A. PIPE INSTALLATION SHALL BE IN ACCORDANCE WITH MANUFACTURERS RECOMMENDATIONS.
 - B. TRENCHING OPERATIONS SHALL INCLUDE ALL NECESSARY DEWATERING.
 - C. TRENCH DETAILS ARE ONLY SHOWN FOR PURPOSES OF MATERIAL PLACEMENT AND MAXIMUM PAY LIMITS.
 - D. AN OSHA APPROVED MOVABLE PROTECTIVE TRENCH SHIELD SHALL BE USED IN ALL UNSHEETED TRENCH AREAS.

MATERIALS

PIPE BEDDING MATERIAL (NYSDOT 1985 EDITION)


NO. 1 CRUSHED STONE OR CRUSHED GRAVEL WITH A GRADATION CONFORMING WITH NYSDOT SECTION 703-02. THE MATERIAL SHALL BE WELL GRADED WITH NO PARTICLES LARGER THAN ONE INCH AND HAVING A MAXIMUM GRADATION MEETING THE LIMITS DESCRIBED IN THE SPECIFICATIONS. THE BEDDING SHALL BE COMPACTED IN 6" LIFTS WITH EQUIPMENT ACCEPTABLE TO THE PIPE MANUFACTURER.

NO SLAG SHALL BE ALLOWED FOR MATERIAL (1)


TYPE 2 CRUSHED STONE OR CRUSHED GRAVEL WITH A GRADATION CONFORMING WITH NYSDOT SECTION 304-2.02 TYPE 2. THE MATERAIL SHALL BE WELL GRADED WITH NO PARTICLES LARGER THAN TWO INCHES AND HAVING A MAXIMUM GRADATION MEETING THE LIMITS DESCRIBED IN THE SPECIFICATIONS. THE BEDDING SHALL BE COMPACTED IN 6" LIFTS WITH EQUIPMENT ACCEPTABLE TO THE PIPE MANUFACTURER.

NO SLAG SHALL BE ALLOWED FOR MATERIAL (2)


TRENCH SECTION IN PAVED AREAS

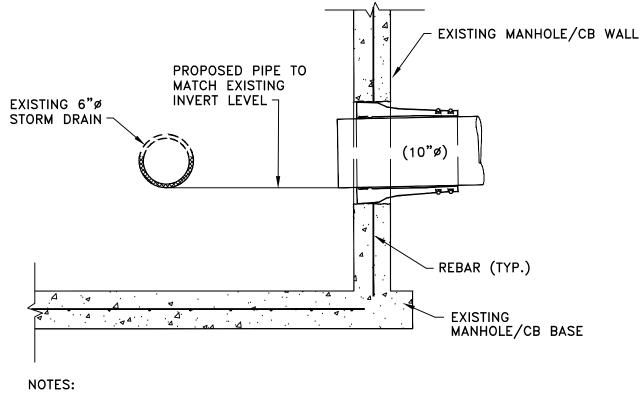

- 1. CORE DRILL ENTRANCE HOLE IN PRECAST MANHOLE BARREL, BASE AND/OR BENCH FOR REQUIRED PIPE CLEARANCE. PER MANUFACTURERS RECOMMENDATIONS.
- 2. DOES NOT APPLY TO HOUSE LATERALS.
- 3. WATERTIGHT PIPE TO MANHOLE BOOT SEAL REQUIRED FOR ALL CORE DRILLED ENTRANCE HOLES IN MANHOLE BARREL AS SHOWN BELOW.

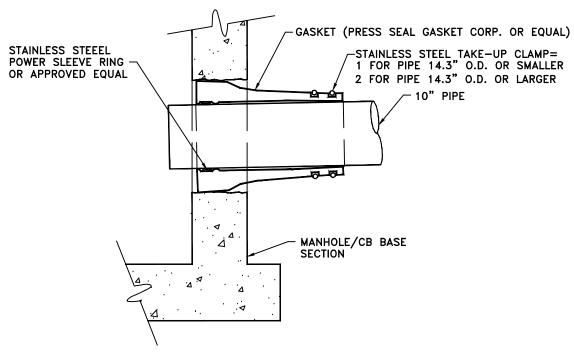

CONNECTION TO EXISTING MANHOLE/CB

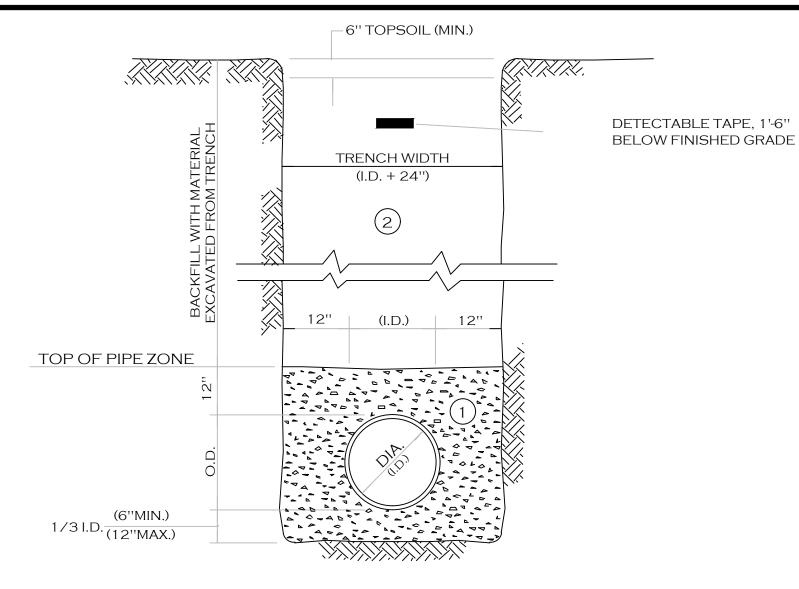

NOTES:

- A. PIPE INSTALLATION SHALL BE IN ACCORDANCE WITH MANUFACTURERS RECOMMENDATIONS.
- B. TRENCHING OPERATIONS SHALL INCLUDE ALL NECESSARY DEWATERING.
- C. TRENCH DETAILS ARE ONLY SHOWN FOR PURPOSES OF MATERIAL PLACEMENT AND MAXIMUM PAY LIMITS.
- D. AN OSHA APPROVED MOVABLE PROTECTIVE TRENCH SHIELD SHALL BE USED IN ALL UNSHEETED TRENCH AREAS.

MATERIALS


PIPE BEDDING MATERIAL (NYSDOT 1985 EDITION)


NO. 1 CRUSHED STONE OR CRUSHED GRAVEL WITH A GRADATION CONFORMING WITH NYSDOT SECTION 703-02. THE MATERIAL SHALL BE WELL GRADED WITH NO PARTICLES LARGER THAN ONE INCH AND HAVING A MAXIMUM GRADATION MEETING THE LIMITS DESCRIBED IN THE SPECIFICATIONS. THE BEDDING SHALL BE COMPACTED IN 6" LIFTS WITH EQUIPMENT ACCEPTABLE TO THE PIPE MANUFACTURER.

NO SLAG SHALL BE ALLOWED FOR MATERIAL (1)


BACKFILL MATERIAL SHALL BE NATIVE SOIL CONTAINING NO UNSUITABLE MATERIAL COMPACTED IN 6" LIFTS.

TRENCH SECTION IN UNPAVED AREAS

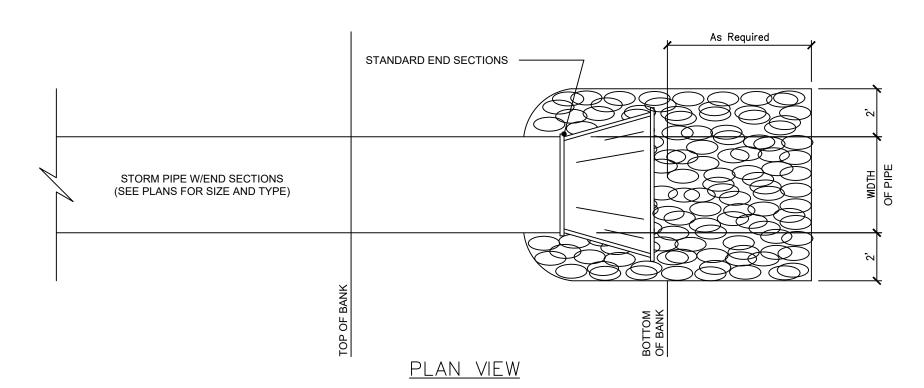


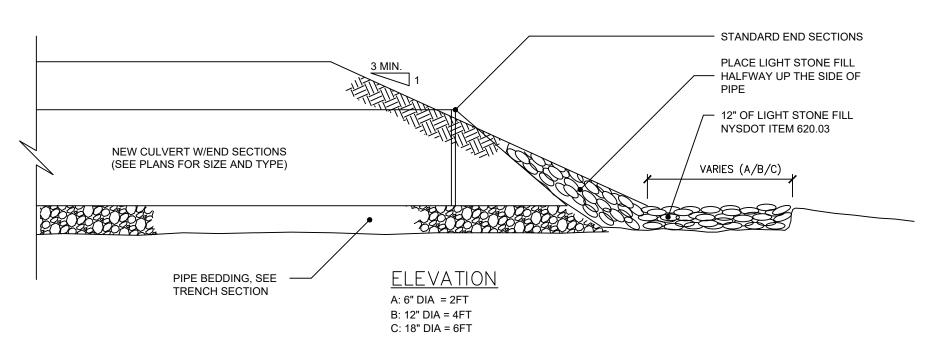

TYPICAL PIPE OUTLET W/END SECTION & RIP RAP

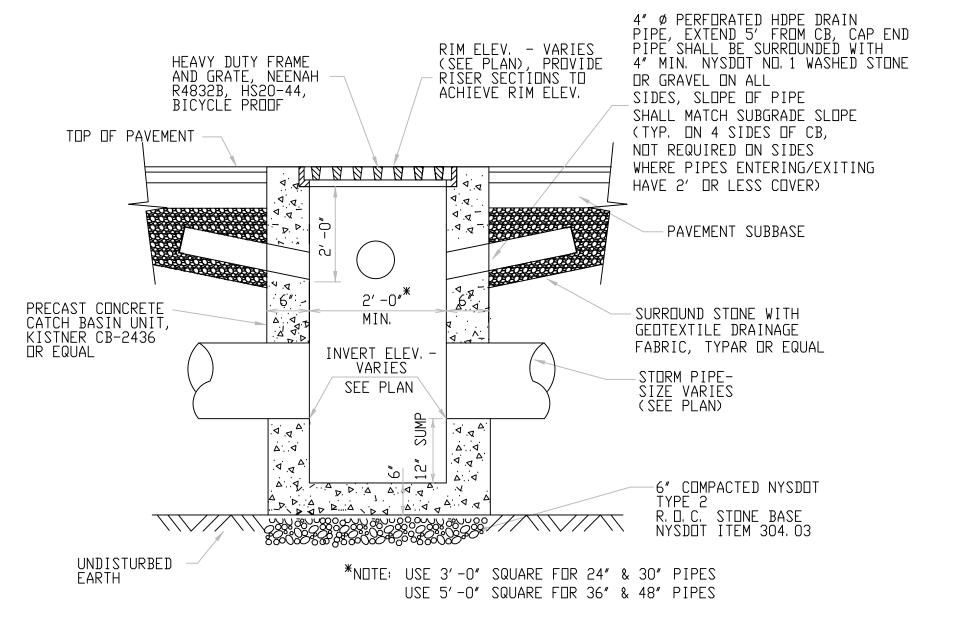

TYPICAL PRECAST CATCH BASIN

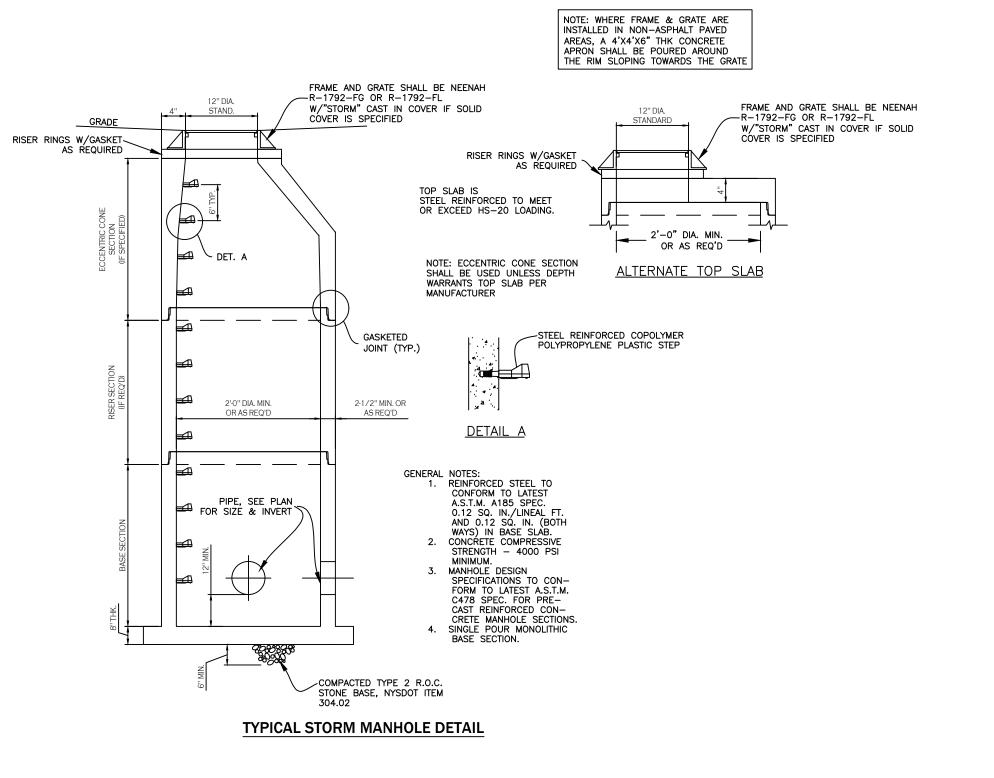

OFFICIAL TOWN USE ONLY

DRAWING REVISIONS: No. DATE BY REMARKS 12 | 05.16.2025 | DZ | Town Comments

SPECIAL INFORMATION: ALL CONTRACTORS SHALL GUARANTEE THEIR WORK FOR A PERIOD OF ONE YEAR FROM THE DATE OF OWNERS ACCEPTANCE.

SHOP DRAWING SUBMITTALS ARE REQUIRED FOR ANY AND ALL STRUCTURES.

UNAUTHORIZED ALTERATIONS OF THIS DOCUMENT ARE IN VIOLATION OF SECTION #7209 OF THE STATE





AREA:

PROPERTY NUMBER: #1723

Bailey 14226

orth N

040

0

mhe

0 **Ⅲ** ◀ PROPOSI MODIFICA


CONSULTANT

JAMES ALLEN RUMSEY

570 DELAWARE AVE., BUFFALO, NY 14202

(716) 886-0211


SEAL

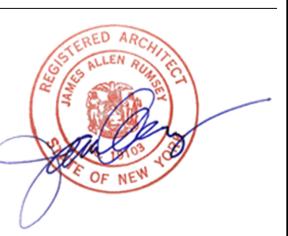



CHECKED BY

Drainage Details


DRAWN BY: DRAWING NO. DMZ

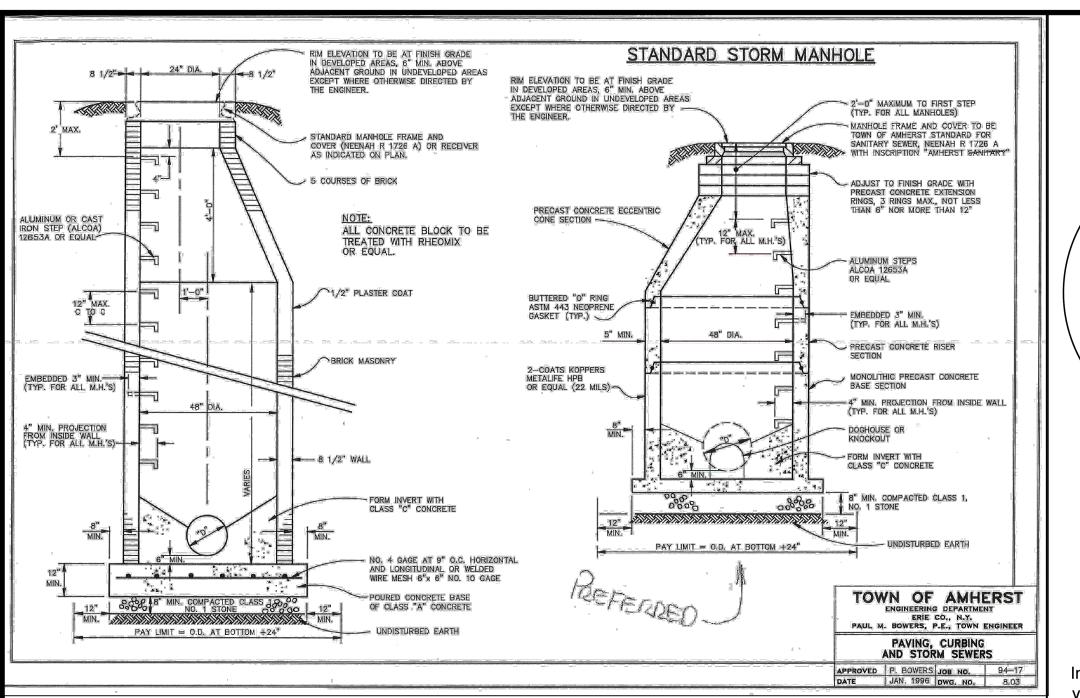

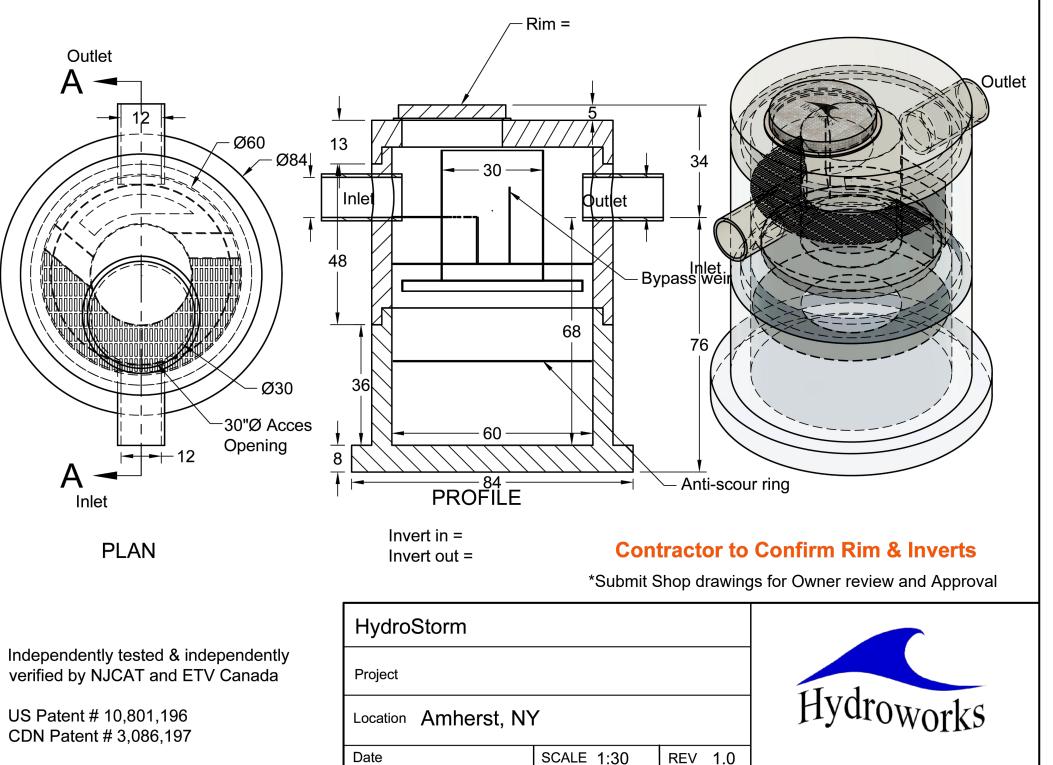

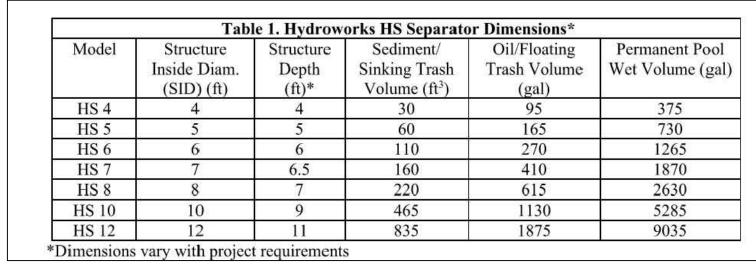

OFFICIAL TOWN USE ONLY

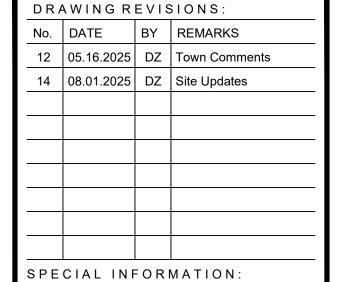

ALL CONTRACTORS SHALL GUARANTEE THEIR WORK FOR A PERIOD OF ONE YEAR FROM THE DATE OF OWNERS ACCEPTANCE.

SHOP DRAWING SUBMITTALS ARE REQUIRED FOR ANY AND ALL STRUCTURES.

UNAUTHORIZED ALTERATIONS OF THIS DOCUMENT ARE IN VIOLATION OF SECTION #7209 OF THE STATE





PROPERTY NUMBER: #1723

Park

AREA:

velopment I North Bailey A st, NY 14226

TION PROPOSEI MODIFICAT **erst Deve** 0 - 6040 No Amherst, l

S

CONSULTANT


0

mhe

JAMES ALLEN RUMSEY

570 DELAWARE AVE., BUFFALO, NY 14202 (716) 886-0211


SEAL

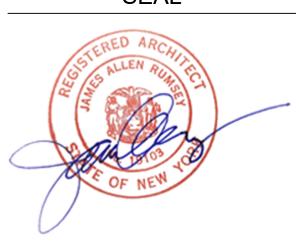



Drainage **Details**


DRAWN BY: DMZ


DRAWING NO. MAO
DATE:
08.30.2023

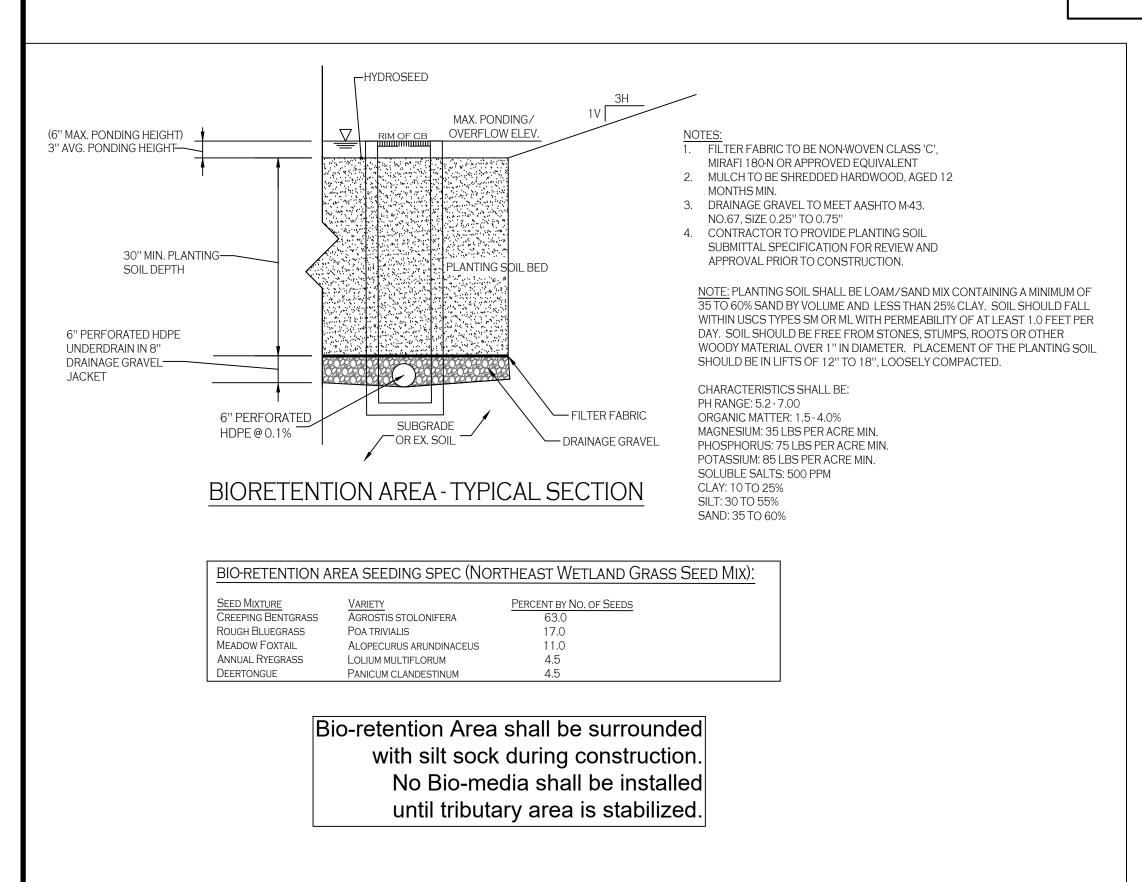


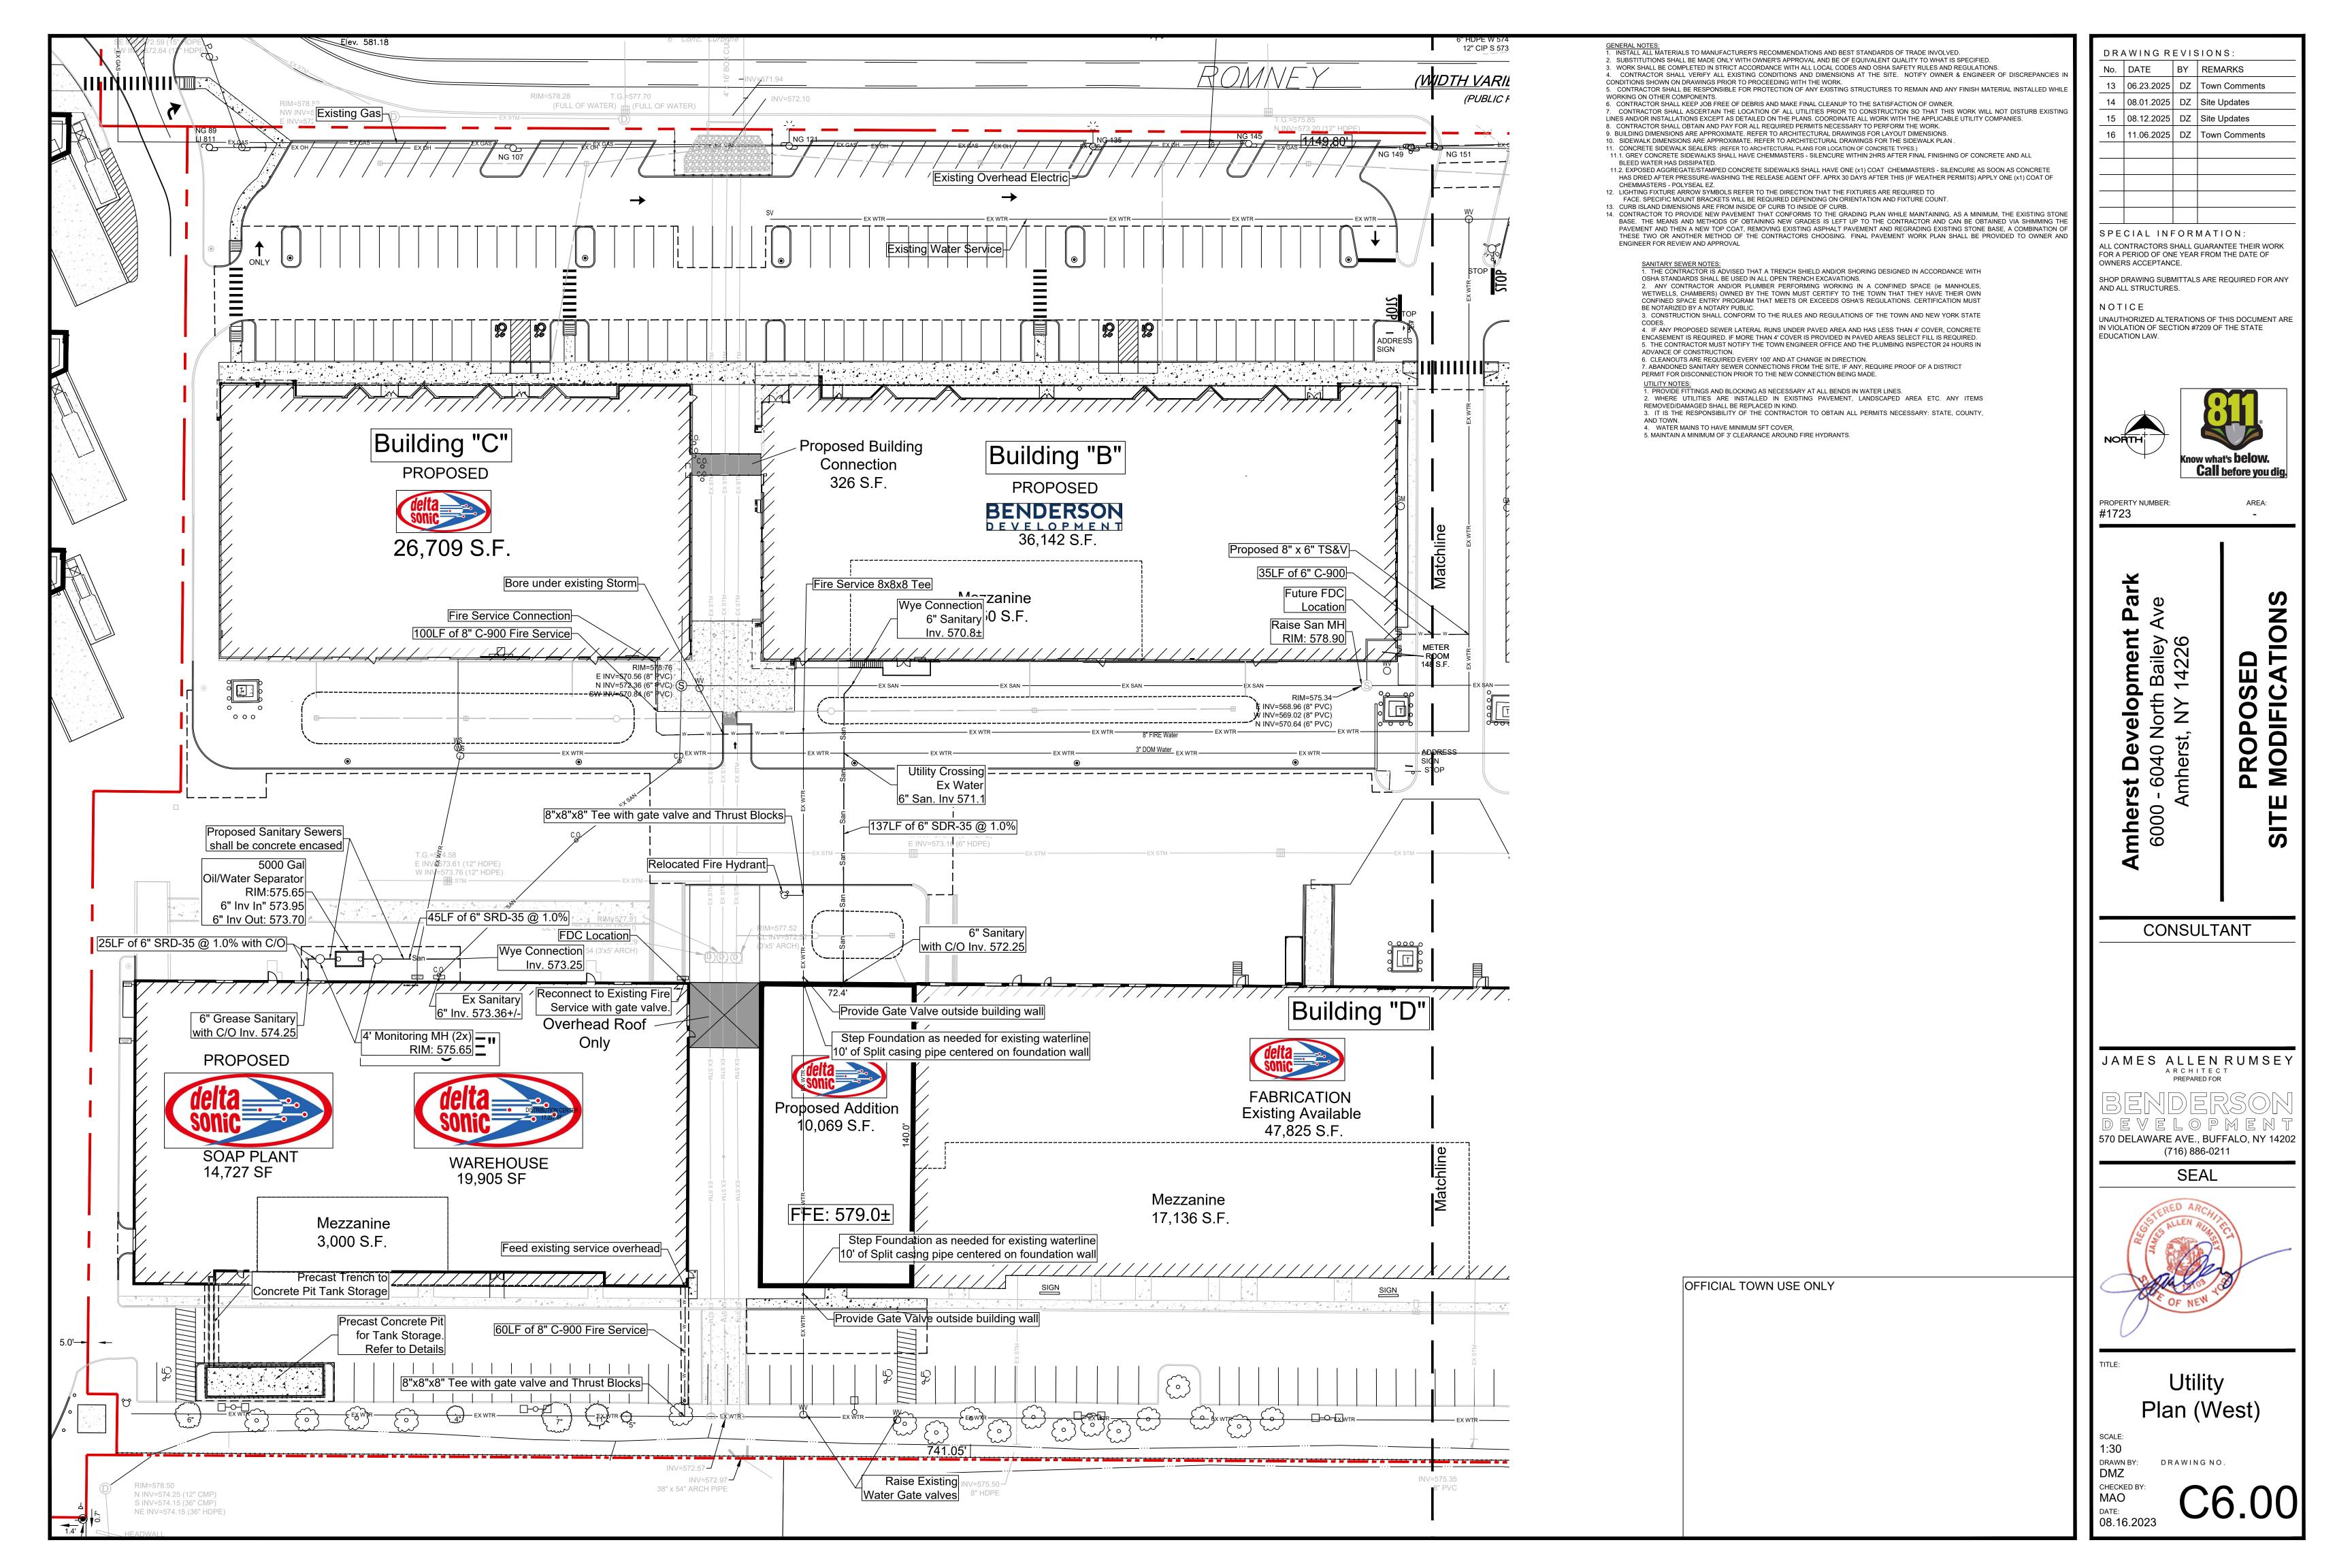


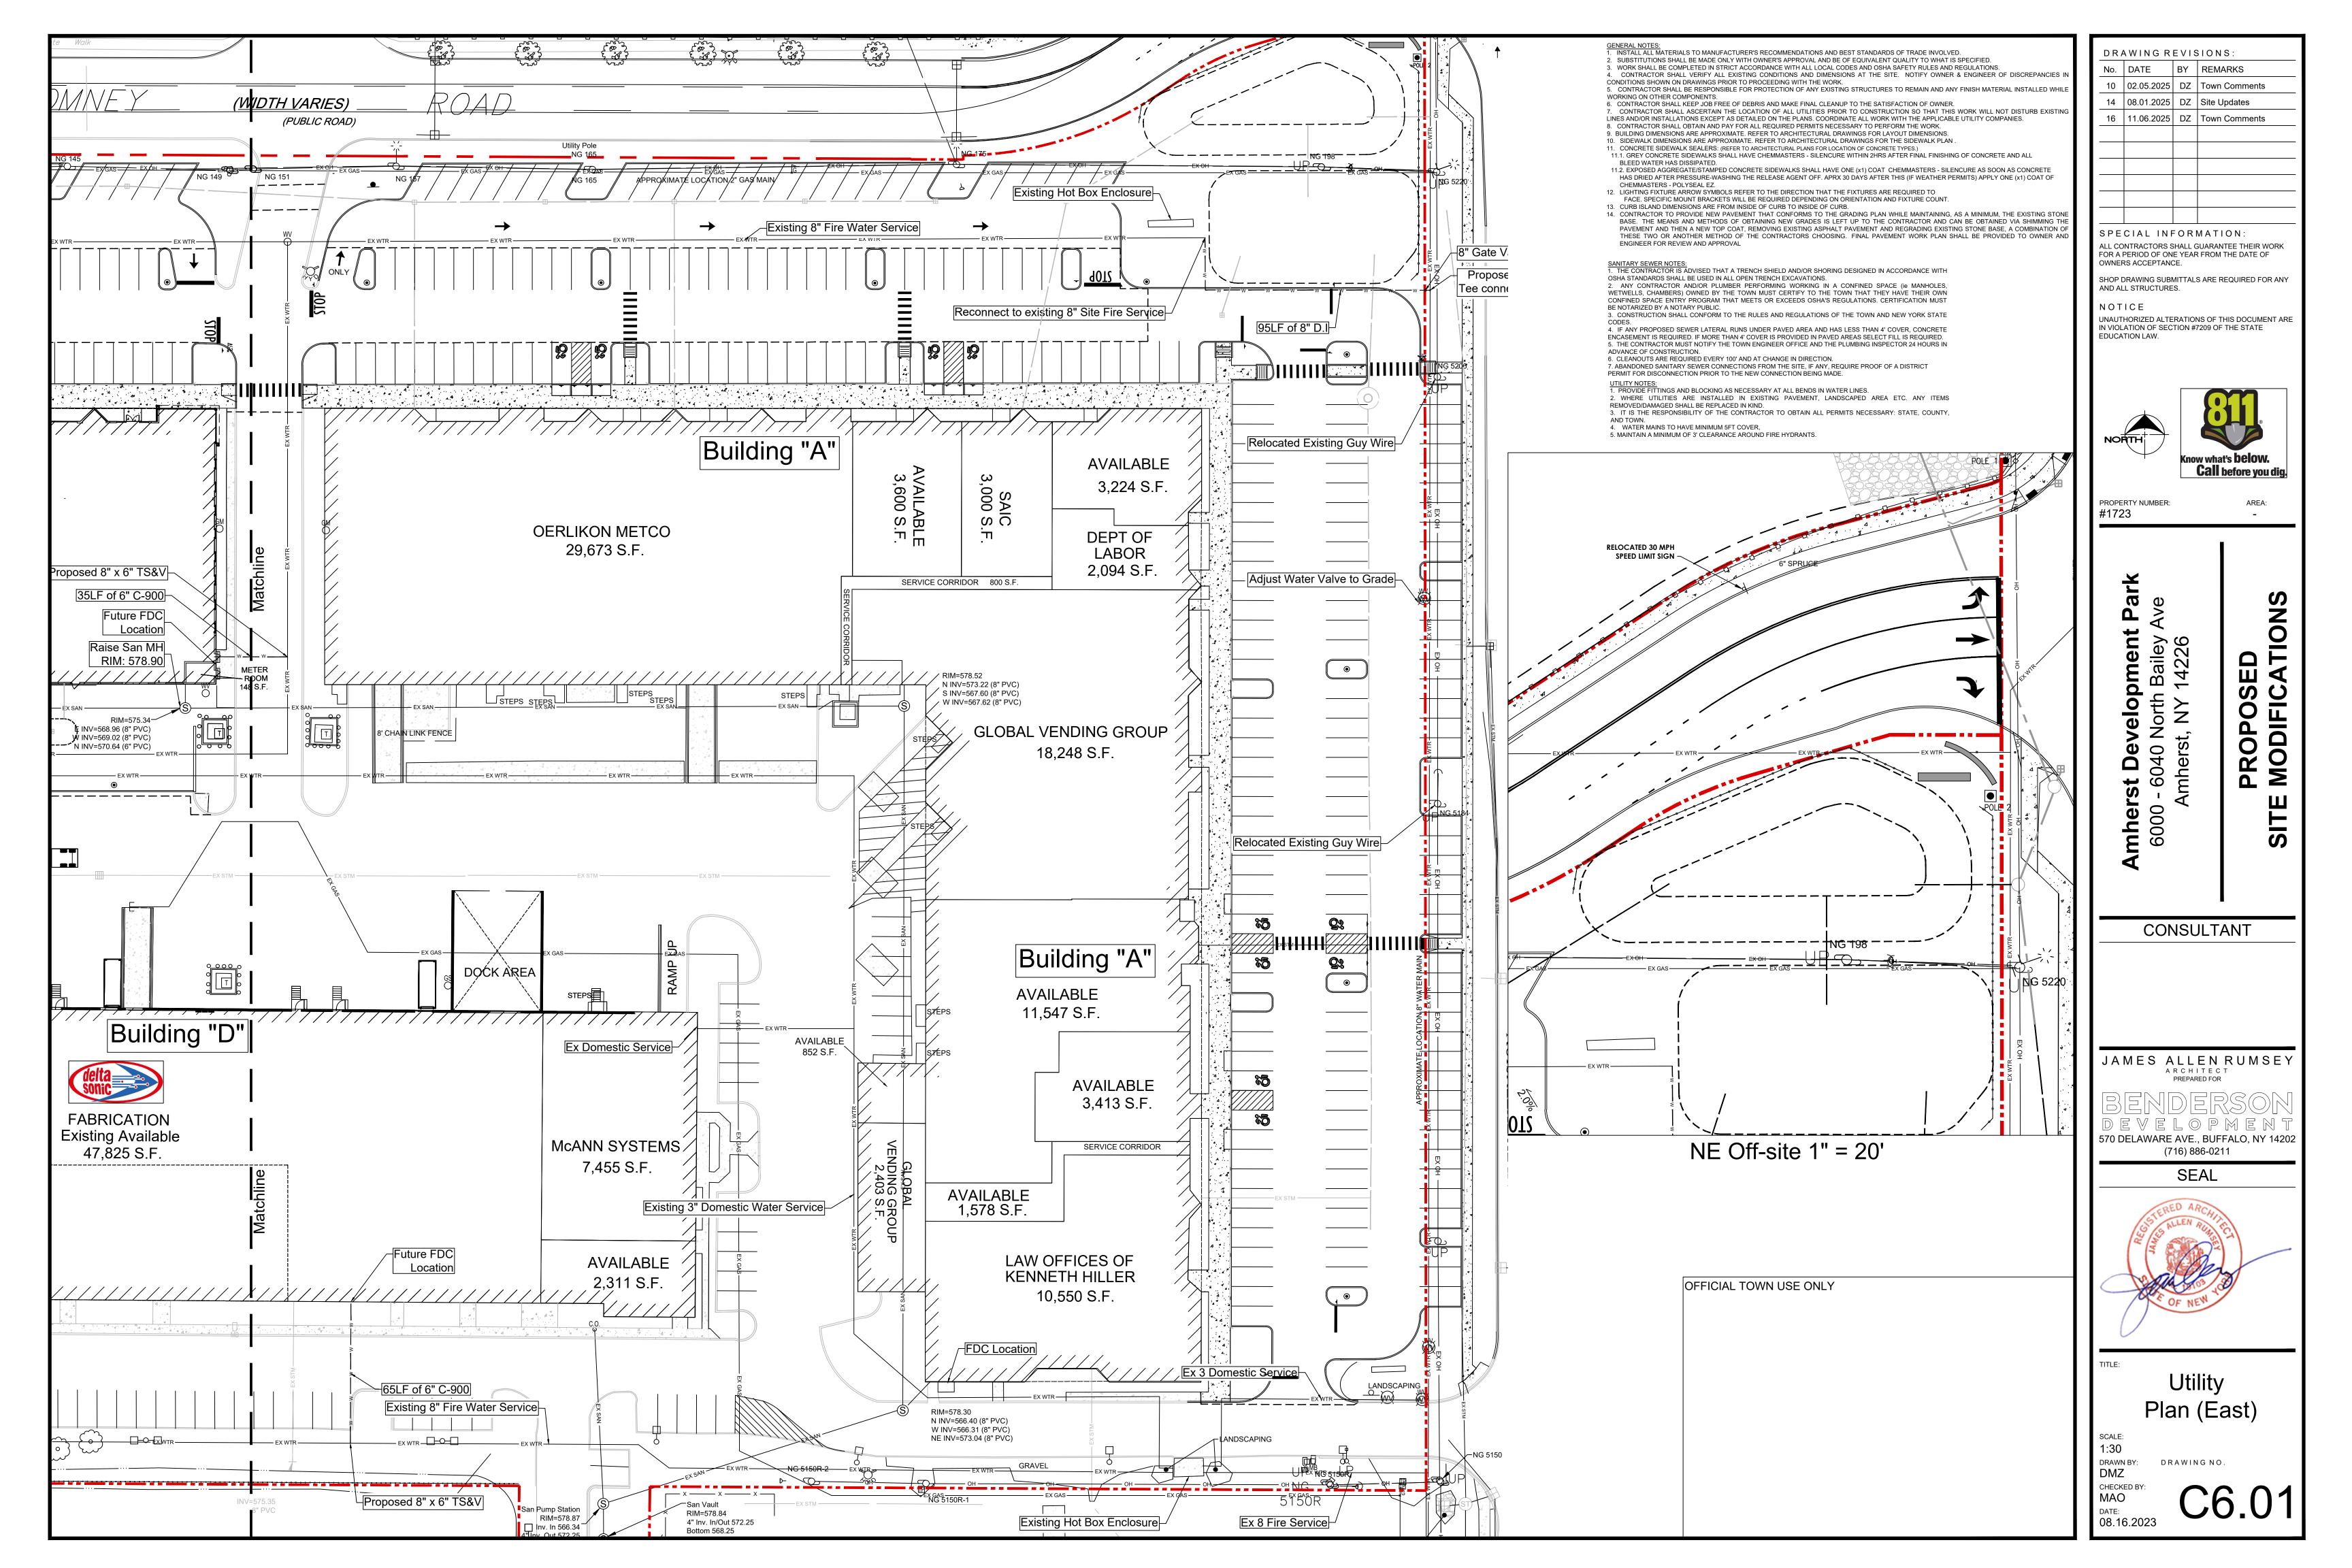


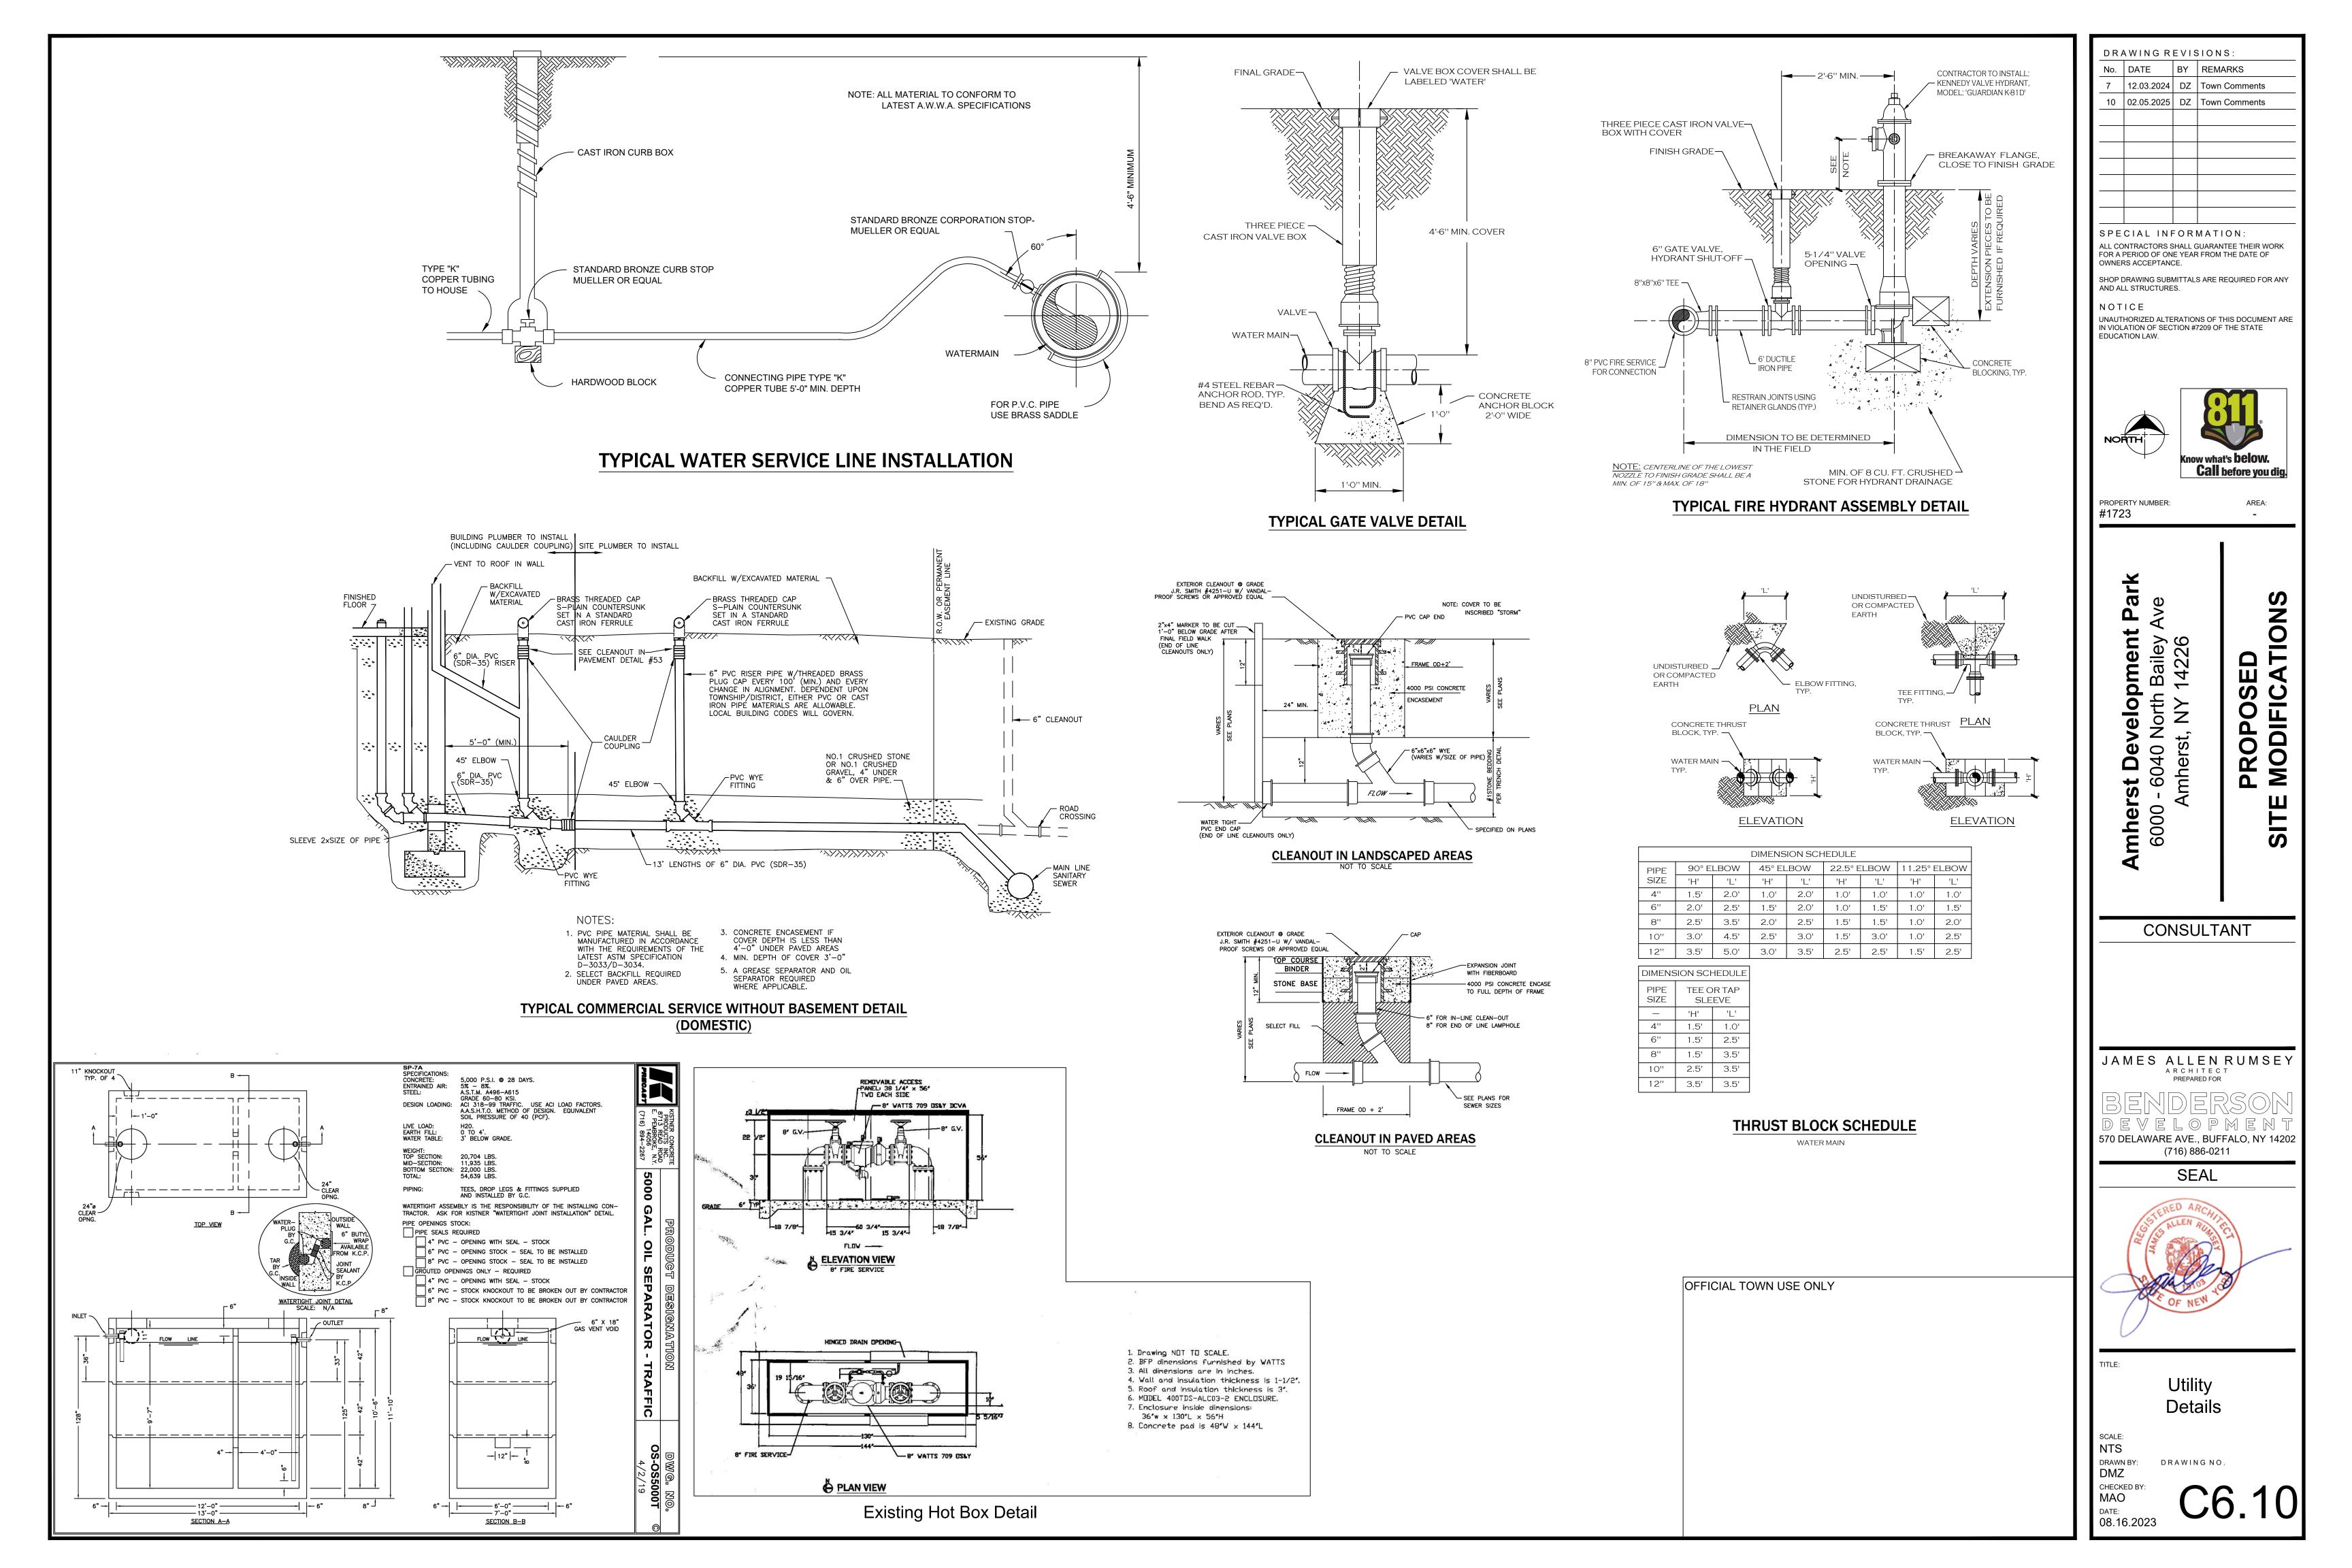


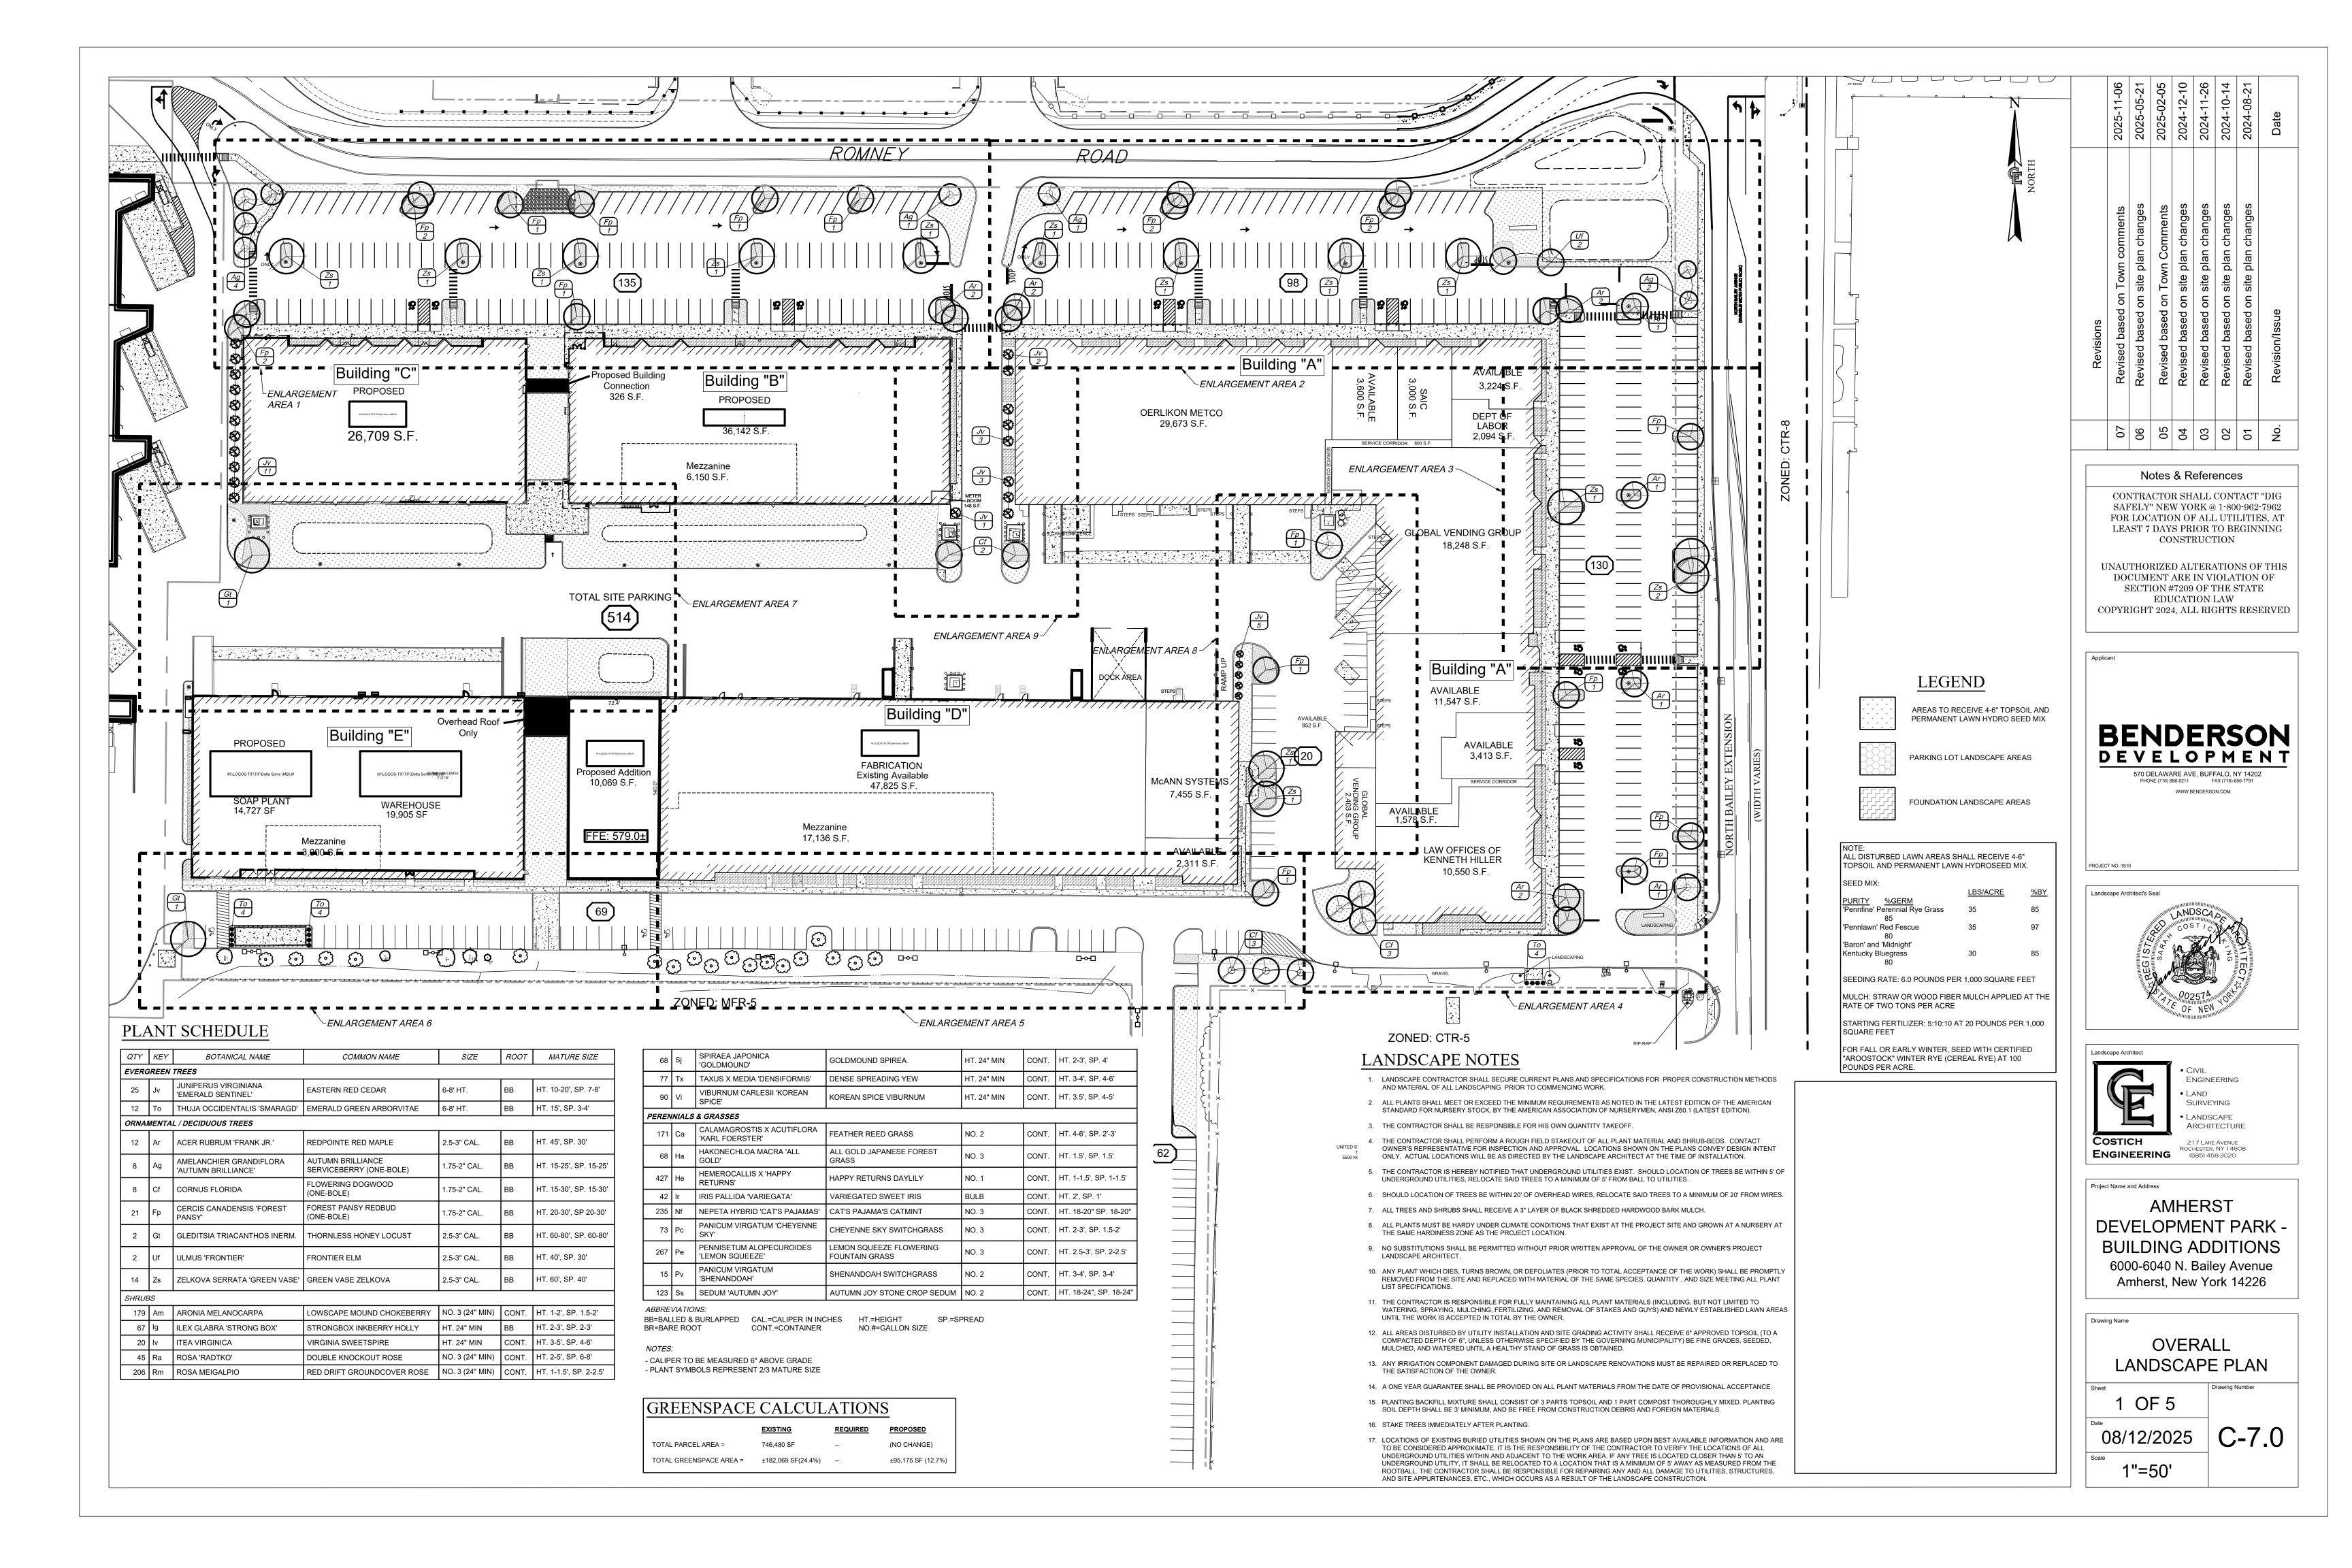

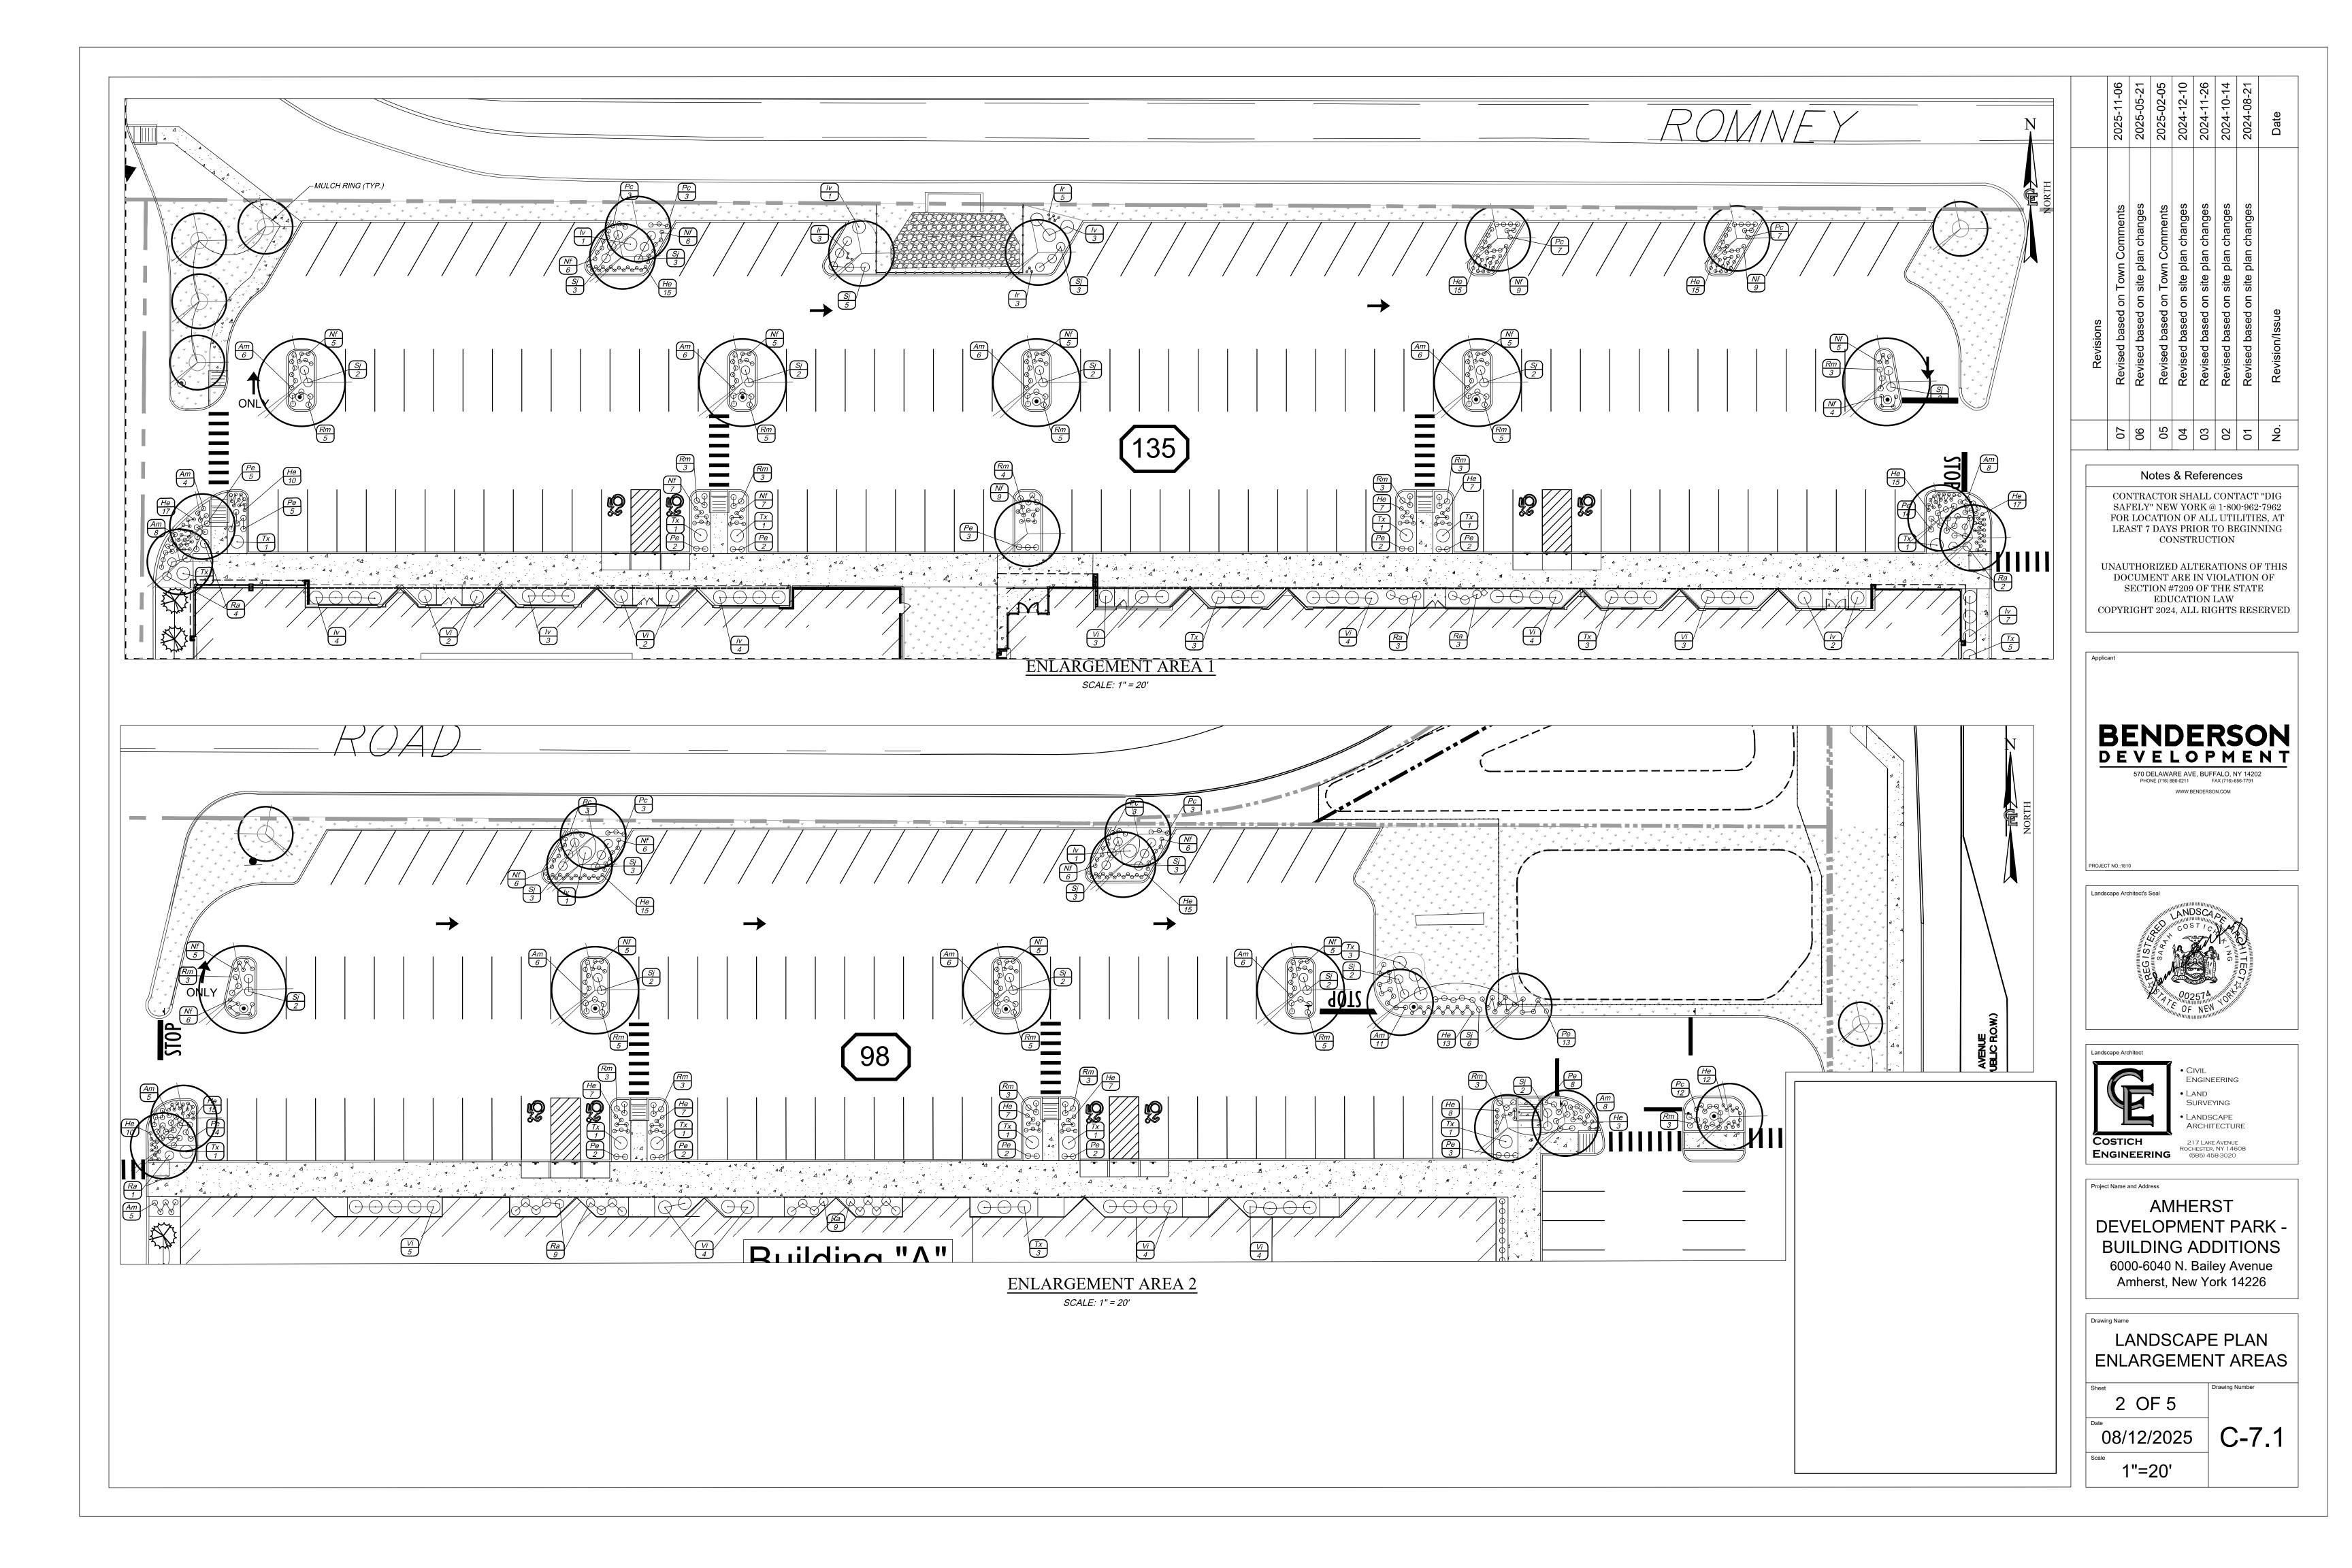


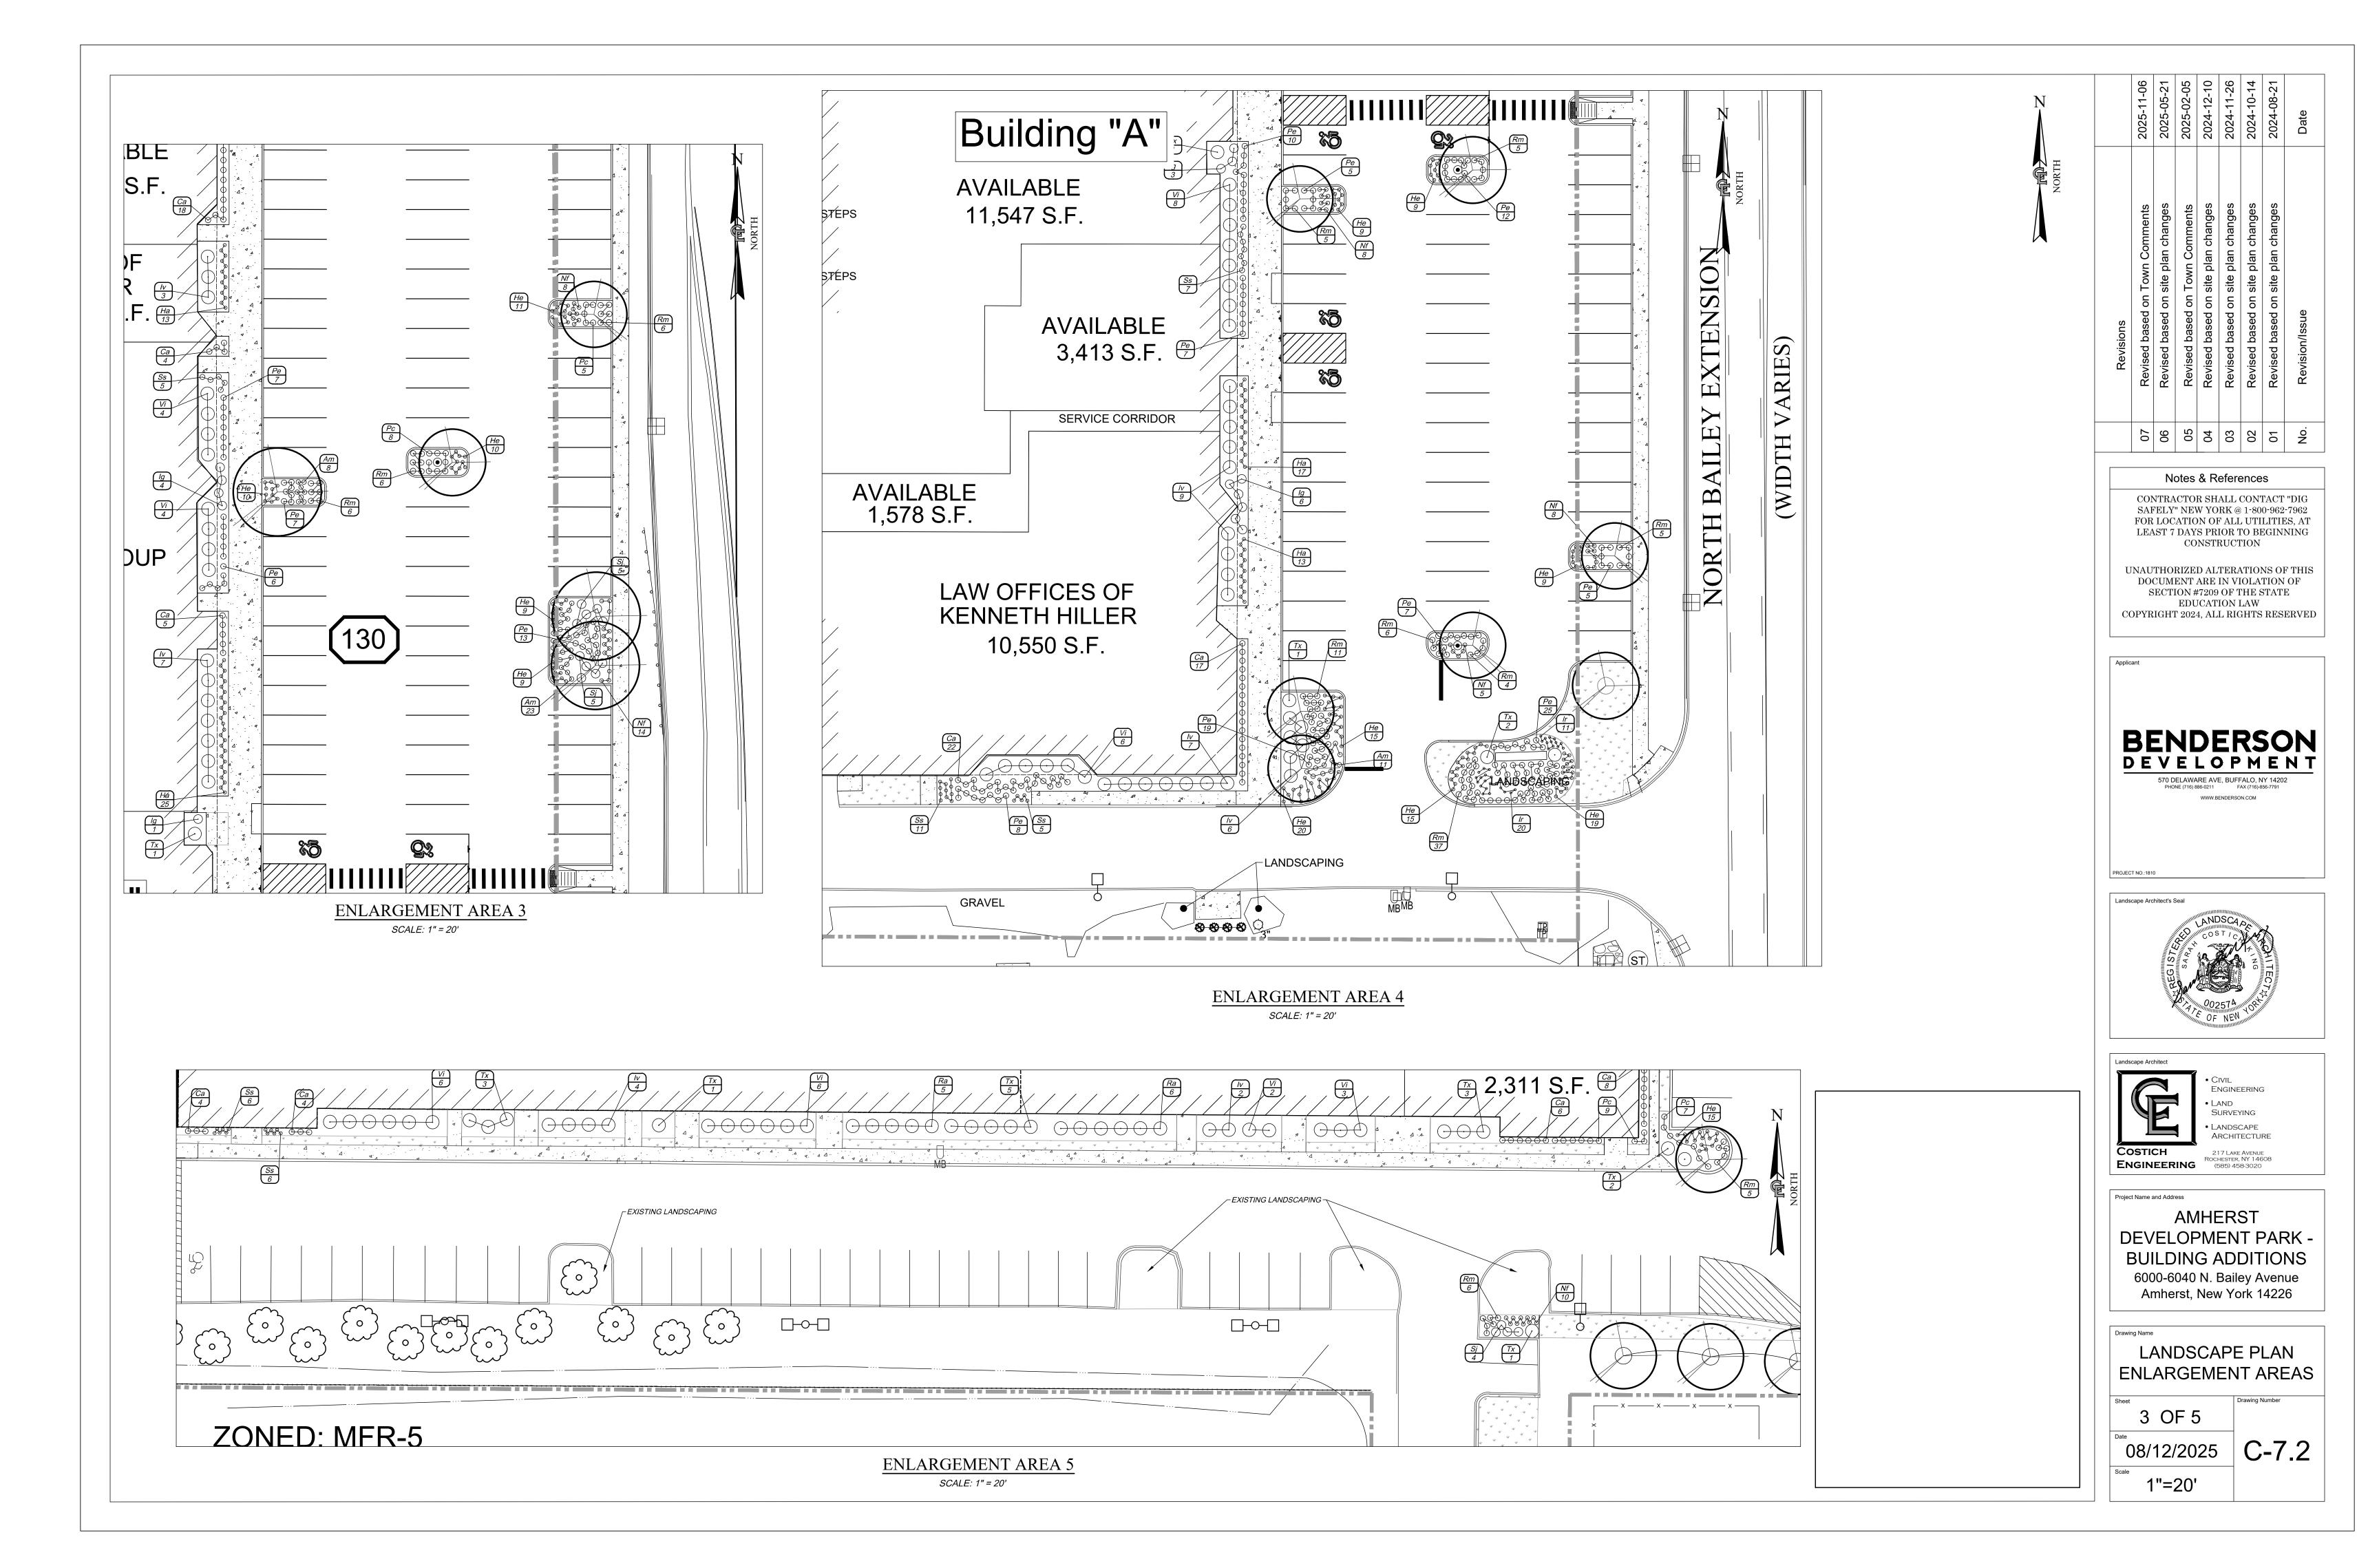

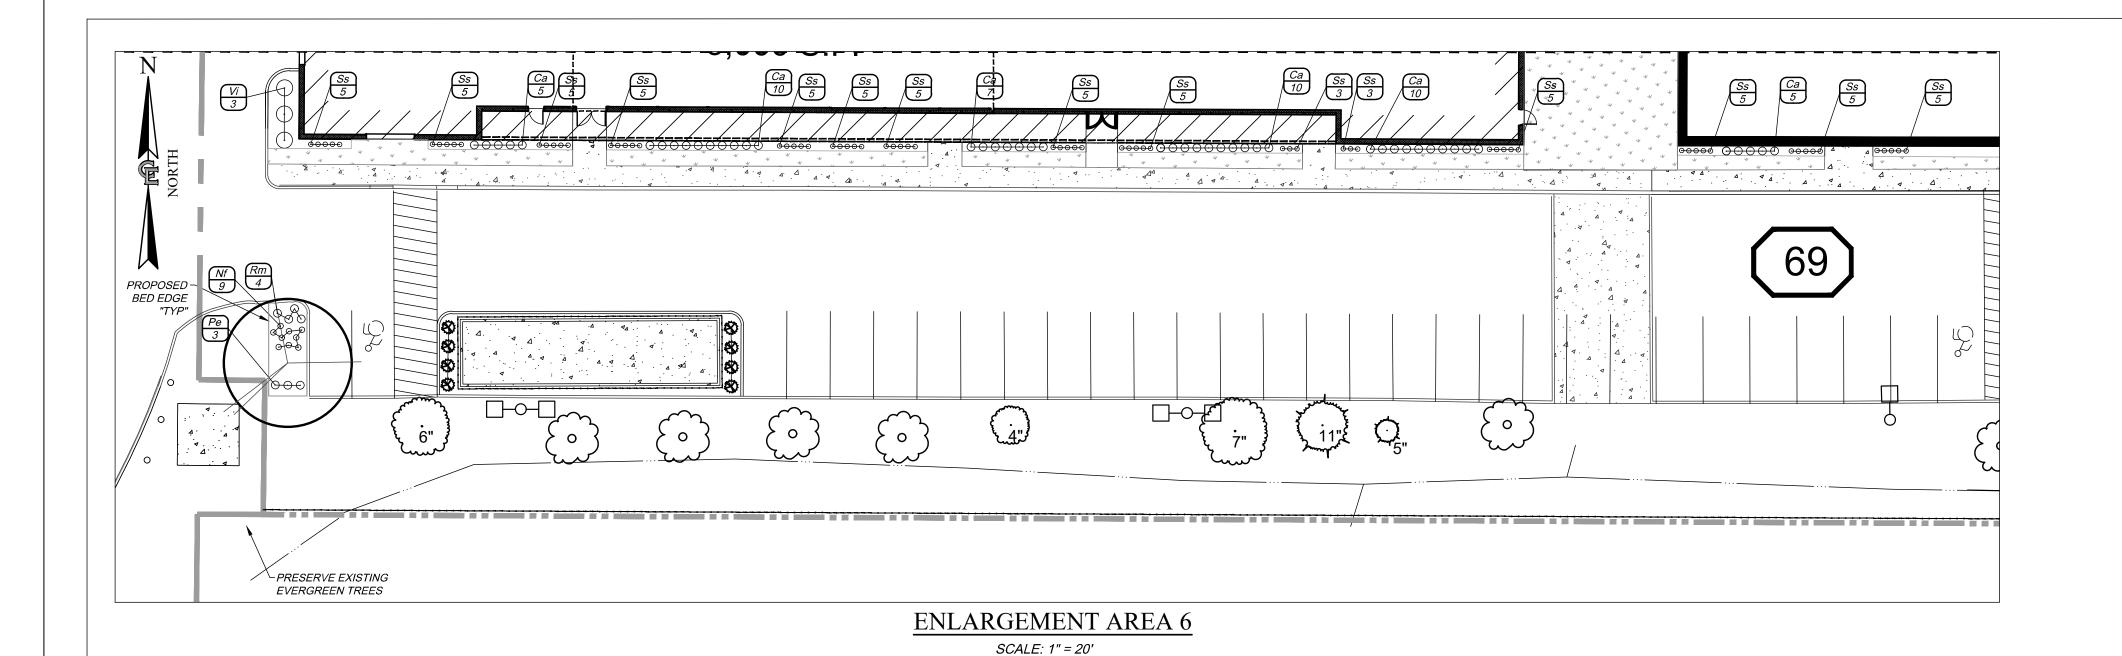


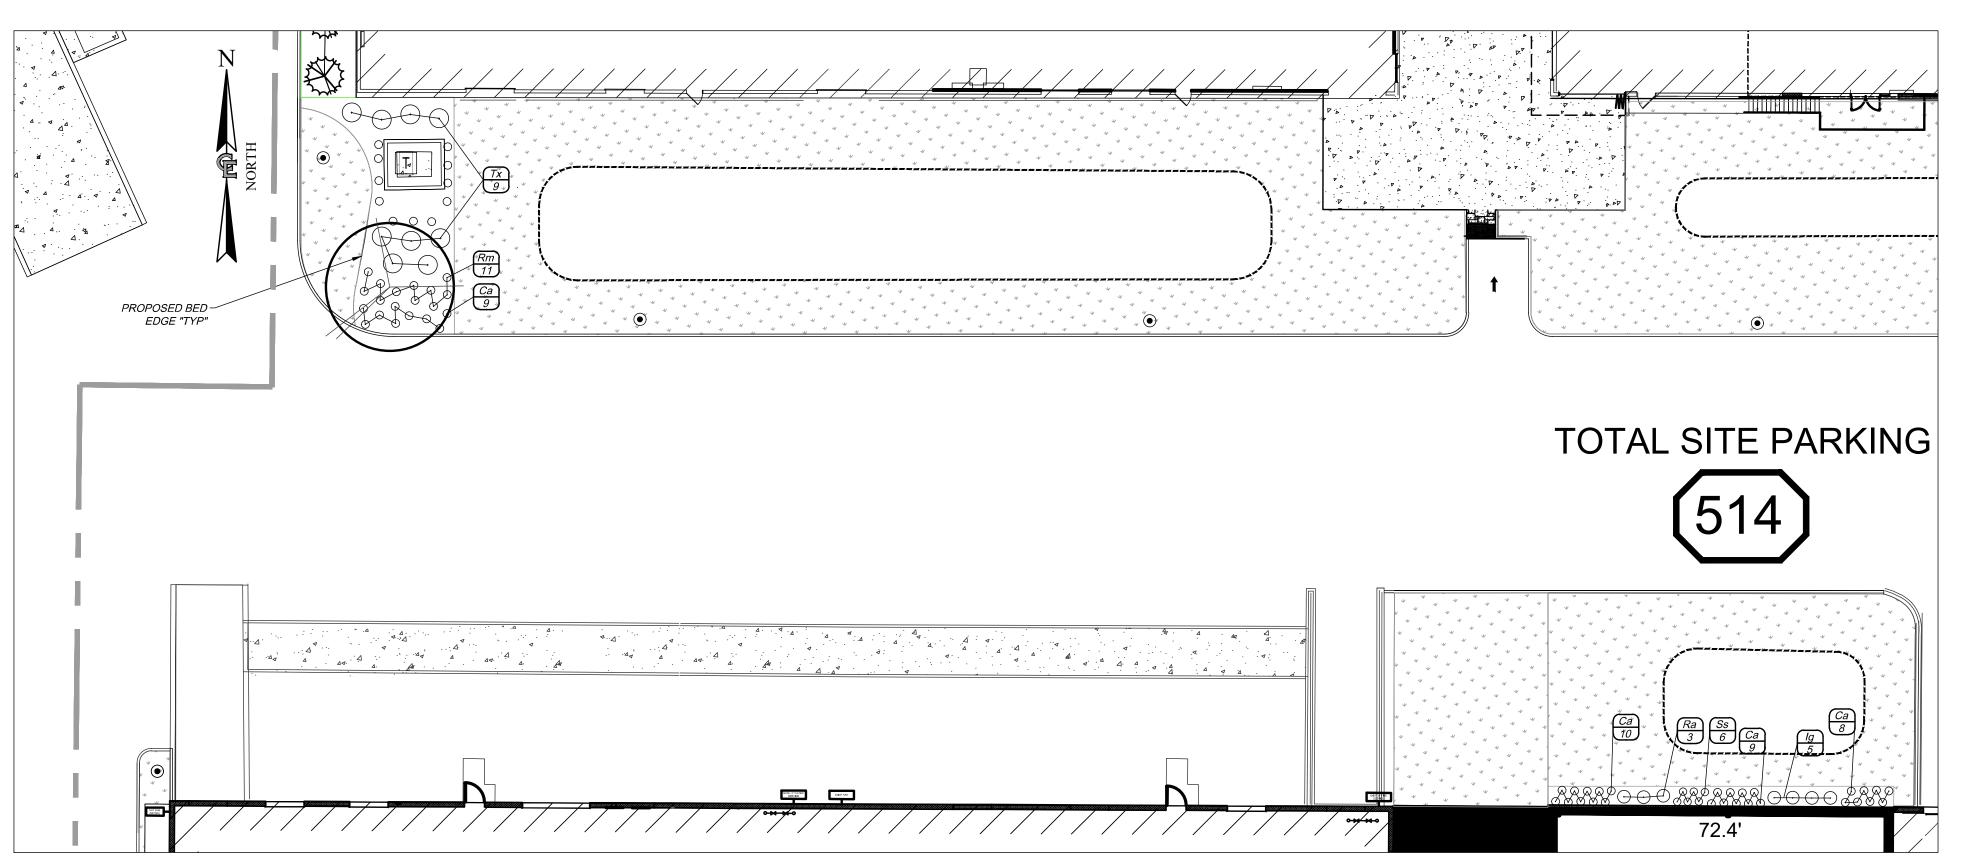



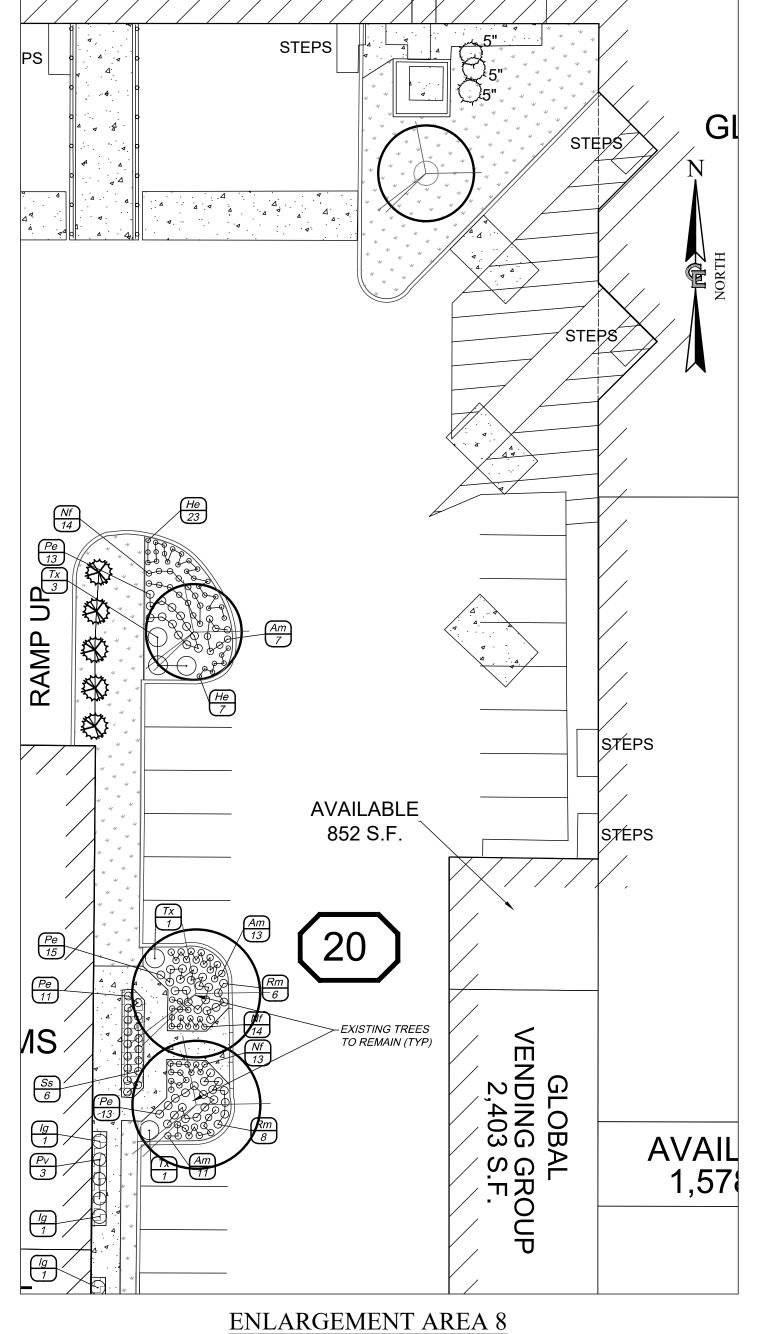

SCALE: 1" = 20'

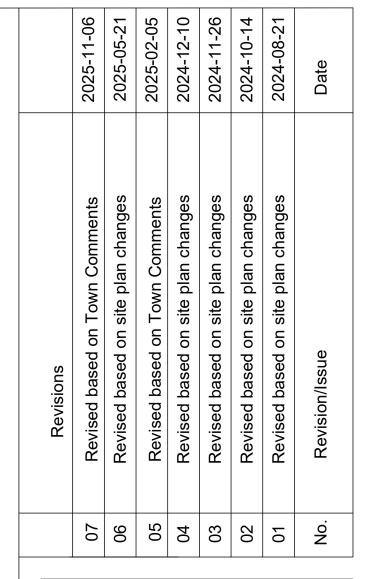

Notes & References

CONTRACTOR SHALL CONTACT "DIG SAFELY" NEW YORK @ 1-800-962-7962 FOR LOCATION OF ALL UTILITIES, AT LEAST 7 DAYS PRIOR TO BEGINNING CONSTRUCTION

UNAUTHORIZED ALTERATIONS OF THIS DOCUMENT ARE IN VIOLATION OF SECTION #7209 OF THE STATE

EDUCATION LAW COPYRIGHT 2024, ALL RIGHTS RESERVED

DEVELOPMENT 570 DELAWARE AVE, BUFFALO, NY 14202 PHONE (716) 886-0211 FAX (716)-856-7791

PROJECT NO.:1810







Project Name and Address

AMHERST DEVELOPMENT PARK -BUILDING ADDITIONS 6000-6040 N. Bailey Avenue Amherst, New York 14226


LANDSCAPE PLAN **ENLARGEMENT AREAS**


4 OF 5


08/12/2025


C-7.3


1"=20'

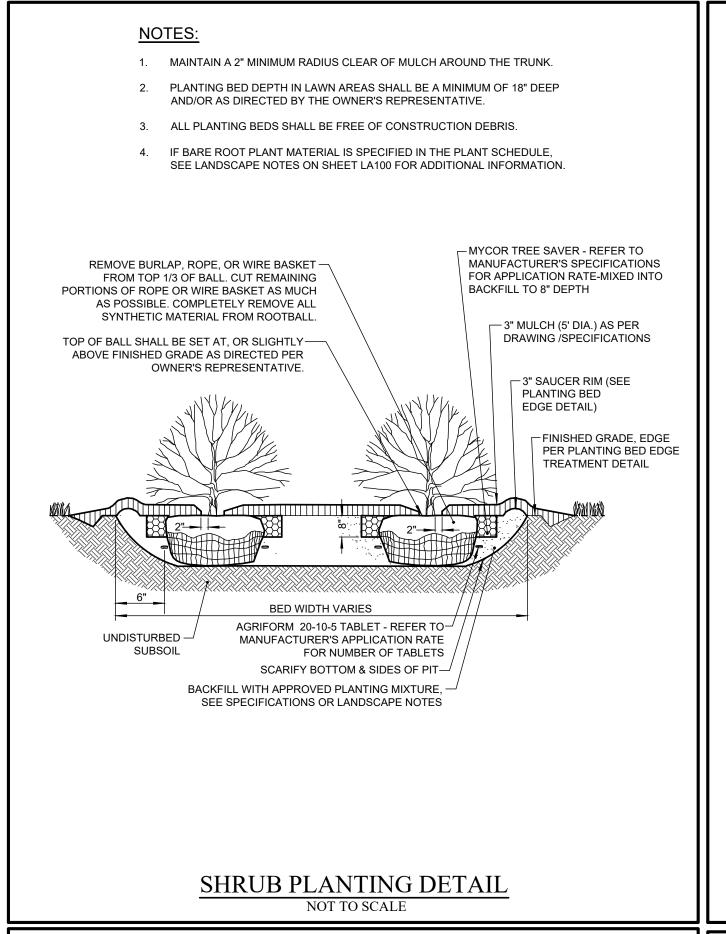


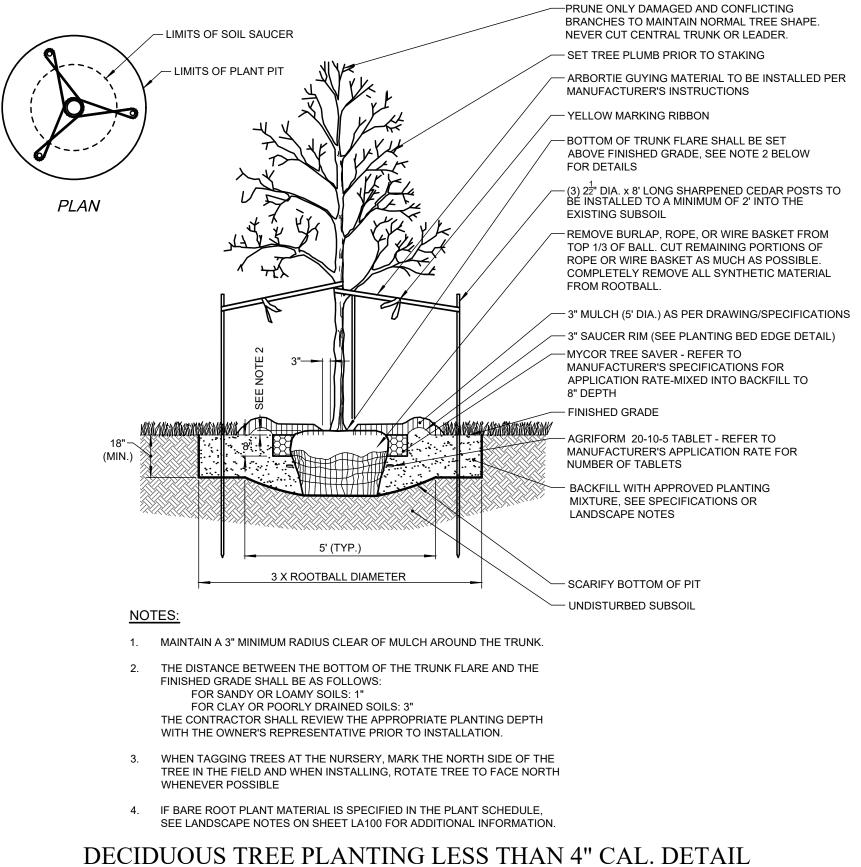

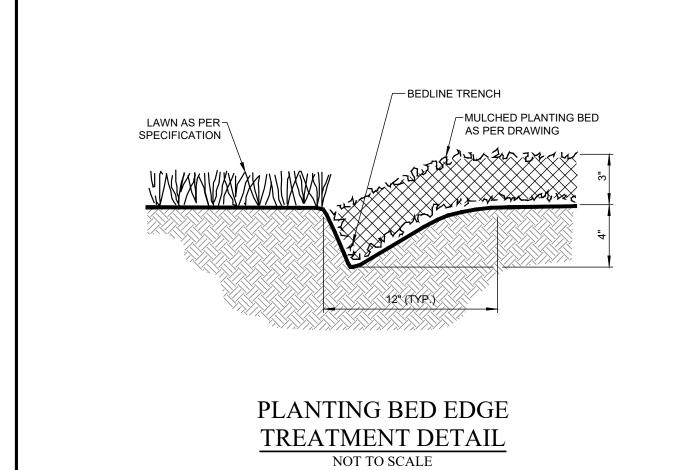

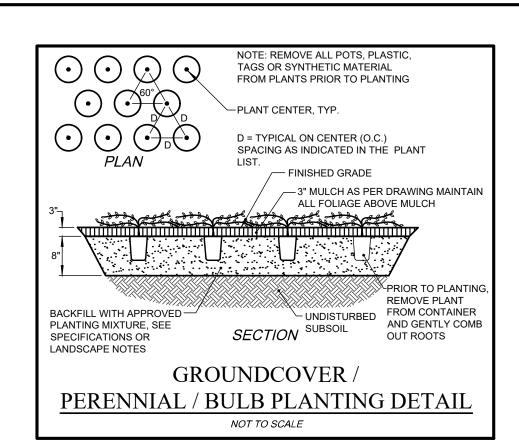

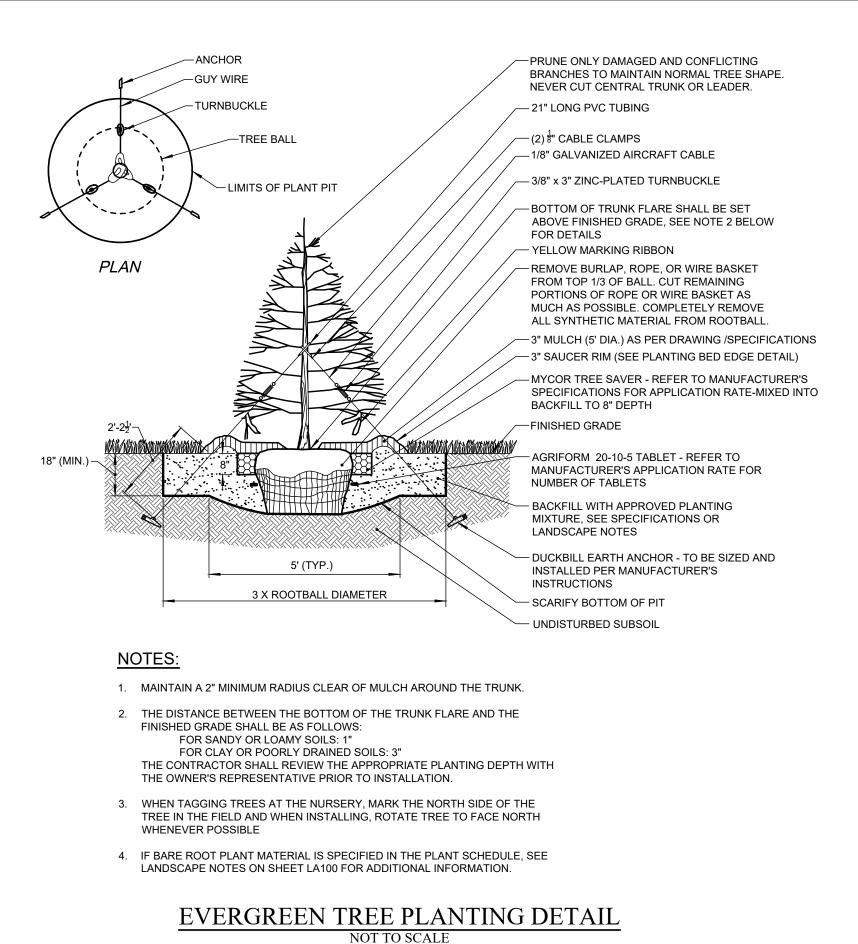

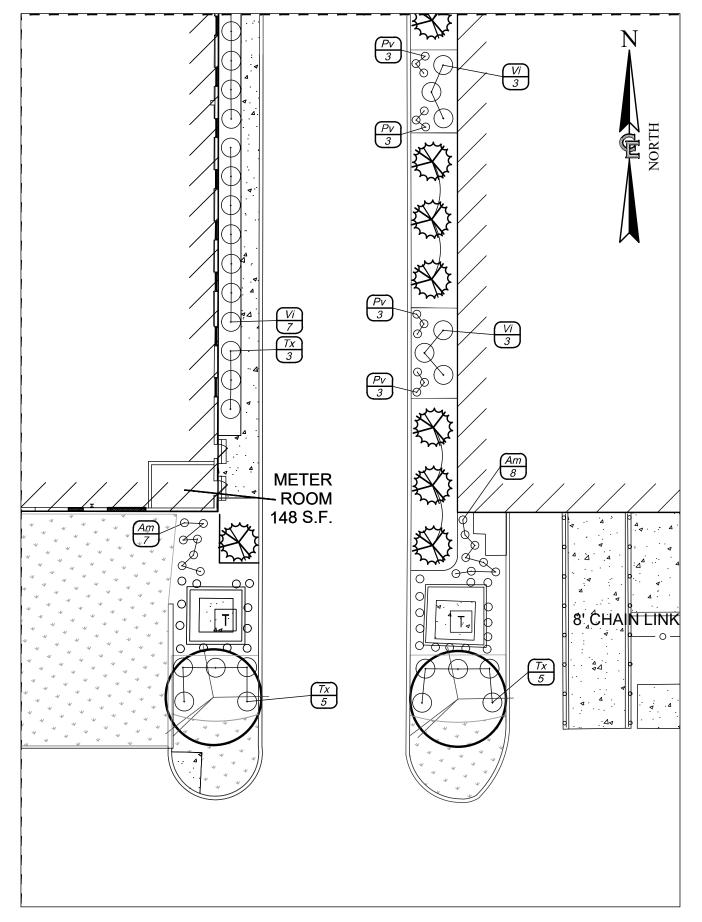

ENLARGEMENT AREA 9 SCALE: 1" = 20'

	Revisions	
90	Revised based on Town Comments	2025-11-06
05	Revised based on Town Comments	2025-02-05
04	Revised based on site plan changes	2024-12-10
03	Revised based on site plan changes	2024-11-26
05	Revised based on site plan changes	2024-10-14
01	Revised based on site plan changes	2024-08-21
No.	Revision/Issue	Date

Notes & References


CONTRACTOR SHALL CONTACT "DIG SAFELY" NEW YORK @ 1-800-962-7962 FOR LOCATION OF ALL UTILITIES, AT LEAST 7 DAYS PRIOR TO BEGINNING CONSTRUCTION

UNAUTHORIZED ALTERATIONS OF THIS DOCUMENT ARE IN VIOLATION OF SECTION #7209 OF THE STATE

EDUCATION LAW COPYRIGHT 2024, ALL RIGHTS RESERVED



PROJECT NO.:1810

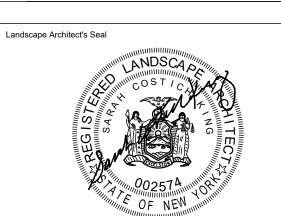





Project Name and Address **AMHERST DEVELOPMENT PARK -BUILDING ADDITIONS** 6000-6040 N. Bailey Avenue

Amherst, New York 14226


LANDSCAPE PLAN ENLARGEMENT AREAS & **DETAILS**


5 OF 5


1"=20'

C-7.4

08/12/2025

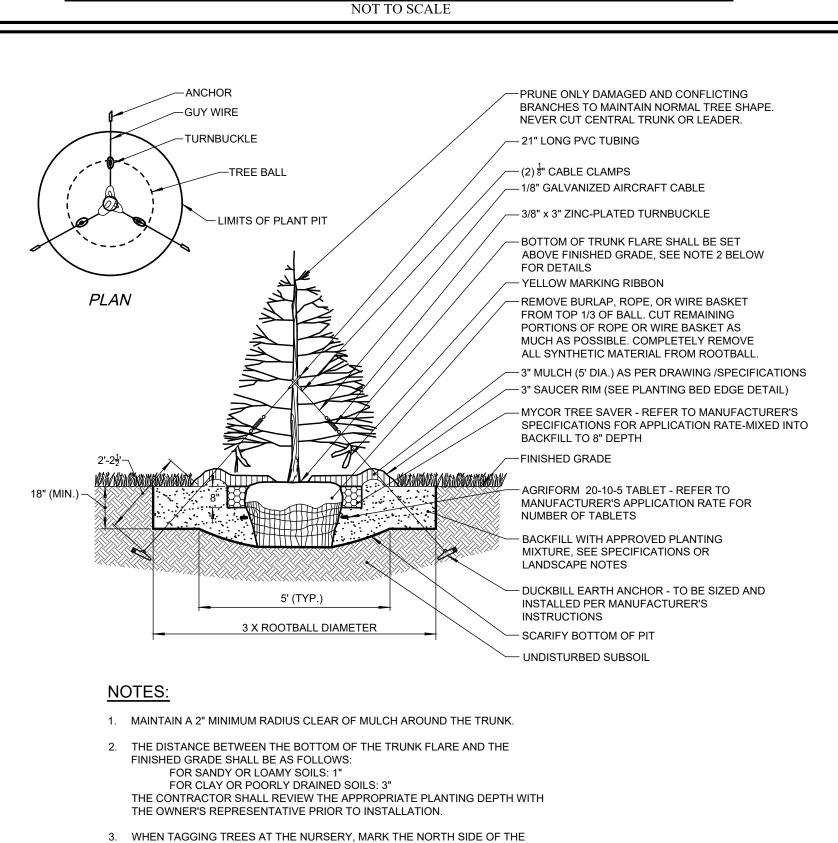

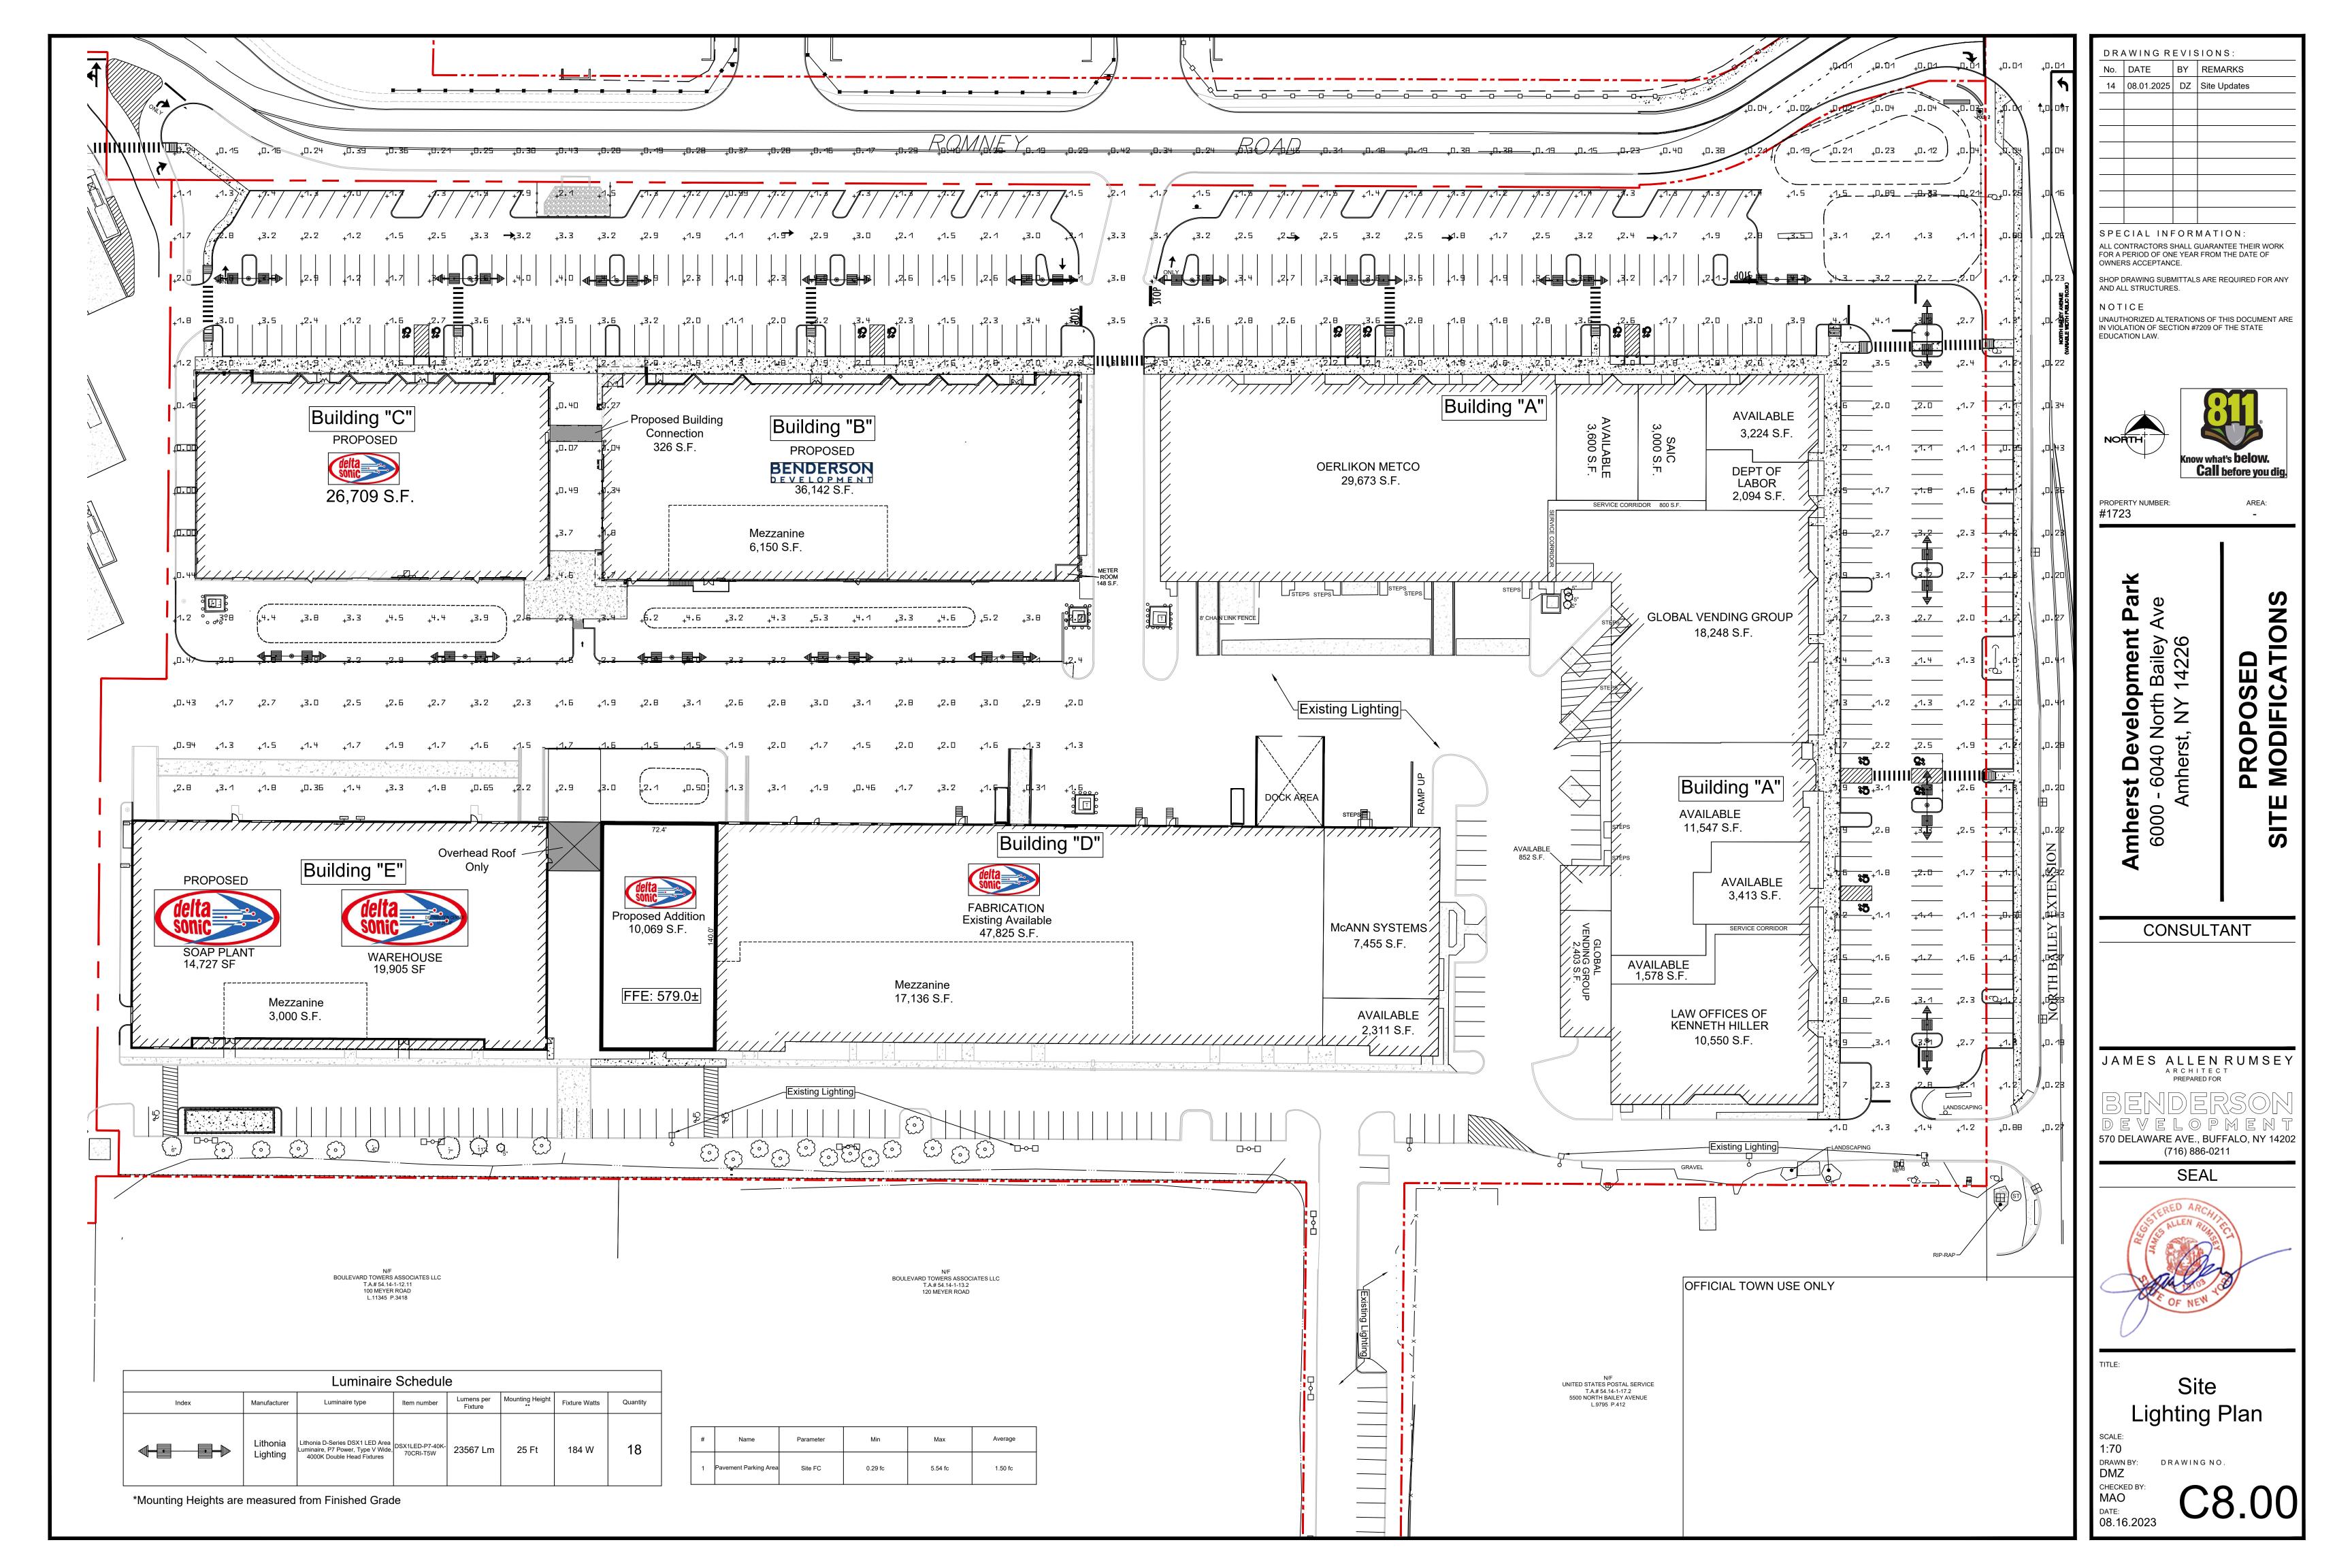

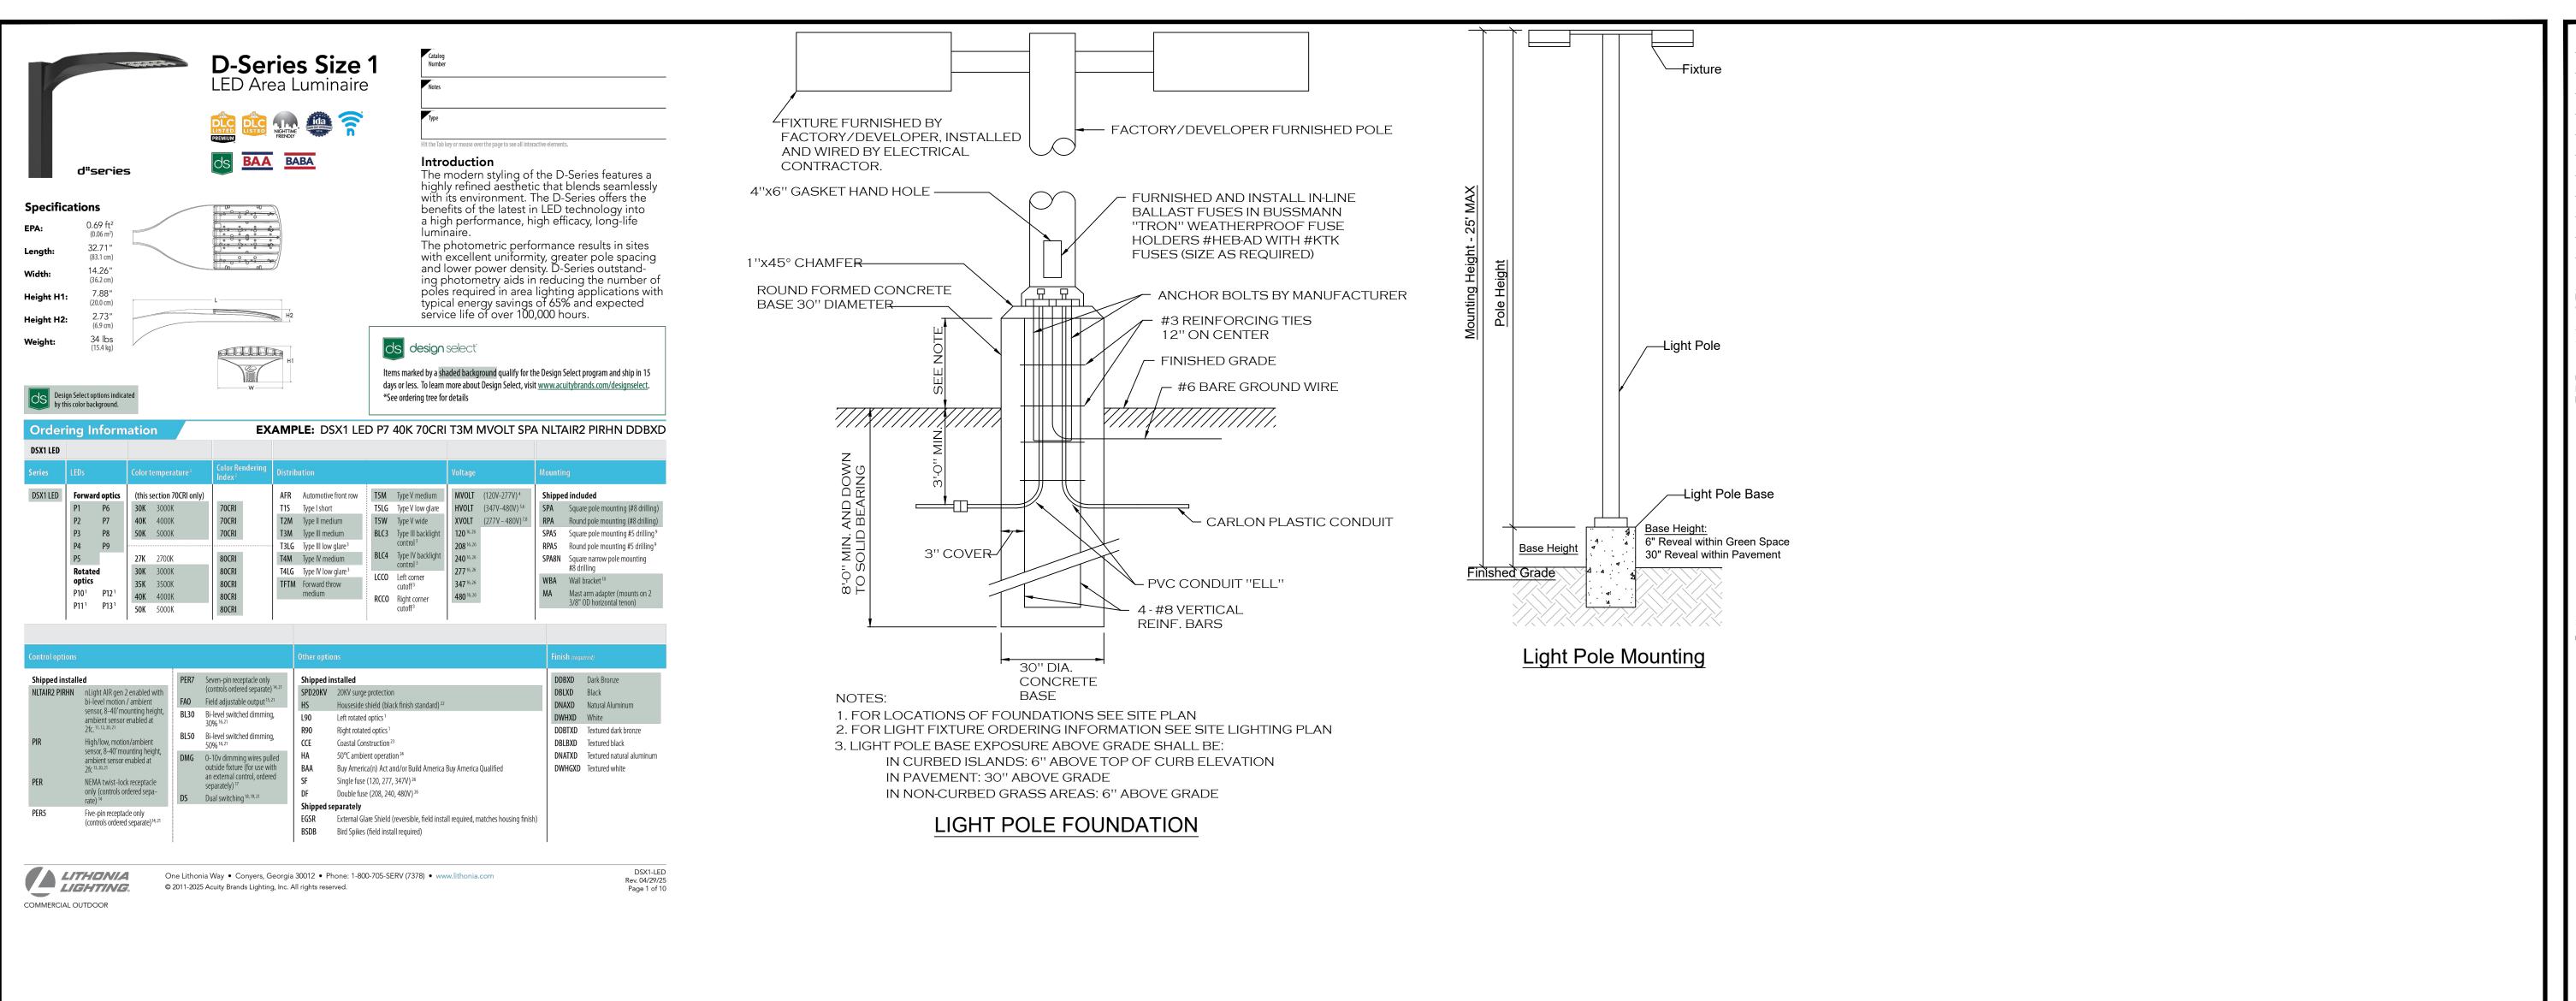

DRAWING REVISIONS: No. DATE BY REMARKS 12.13.2023 DZ POND UPDATES 4 07.31.2024 DZ Site Updates 10 | 02.05.2025 | DZ | Town Comments 13 06.23.2025 DZ Town Comments

SPECIAL INFORMATION: ALL CONTRACTORS SHALL GUARANTEE THEIR WORK FOR A PERIOD OF ONE YEAR FROM THE DATE OF OWNERS ACCEPTANCE.

SHOP DRAWING SUBMITTALS ARE REQUIRED FOR ANY AND ALL STRUCTURES.

UNAUTHORIZED ALTERATIONS OF THIS DOCUMENT ARE IN VIOLATION OF SECTION #7209 OF THE STATE





AREA:

PROPERTY NUMBER: #1723

Park erst Development F 10 - 6040 North Bailey A Amherst, NY 14226

ED VITIONS PROPOSEI MODIFICAT

CONSULTANT


0

mhe

JAMES ALLEN RUMSEY

570 DELAWARE AVE., BUFFALO, NY 14202 (716) 886-0211

SEAL

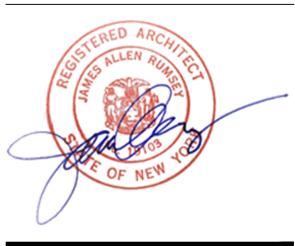

OFFICIAL TOWN USE ONLY

Lighting **Details**

DRAWN BY: DRAWING NO.